


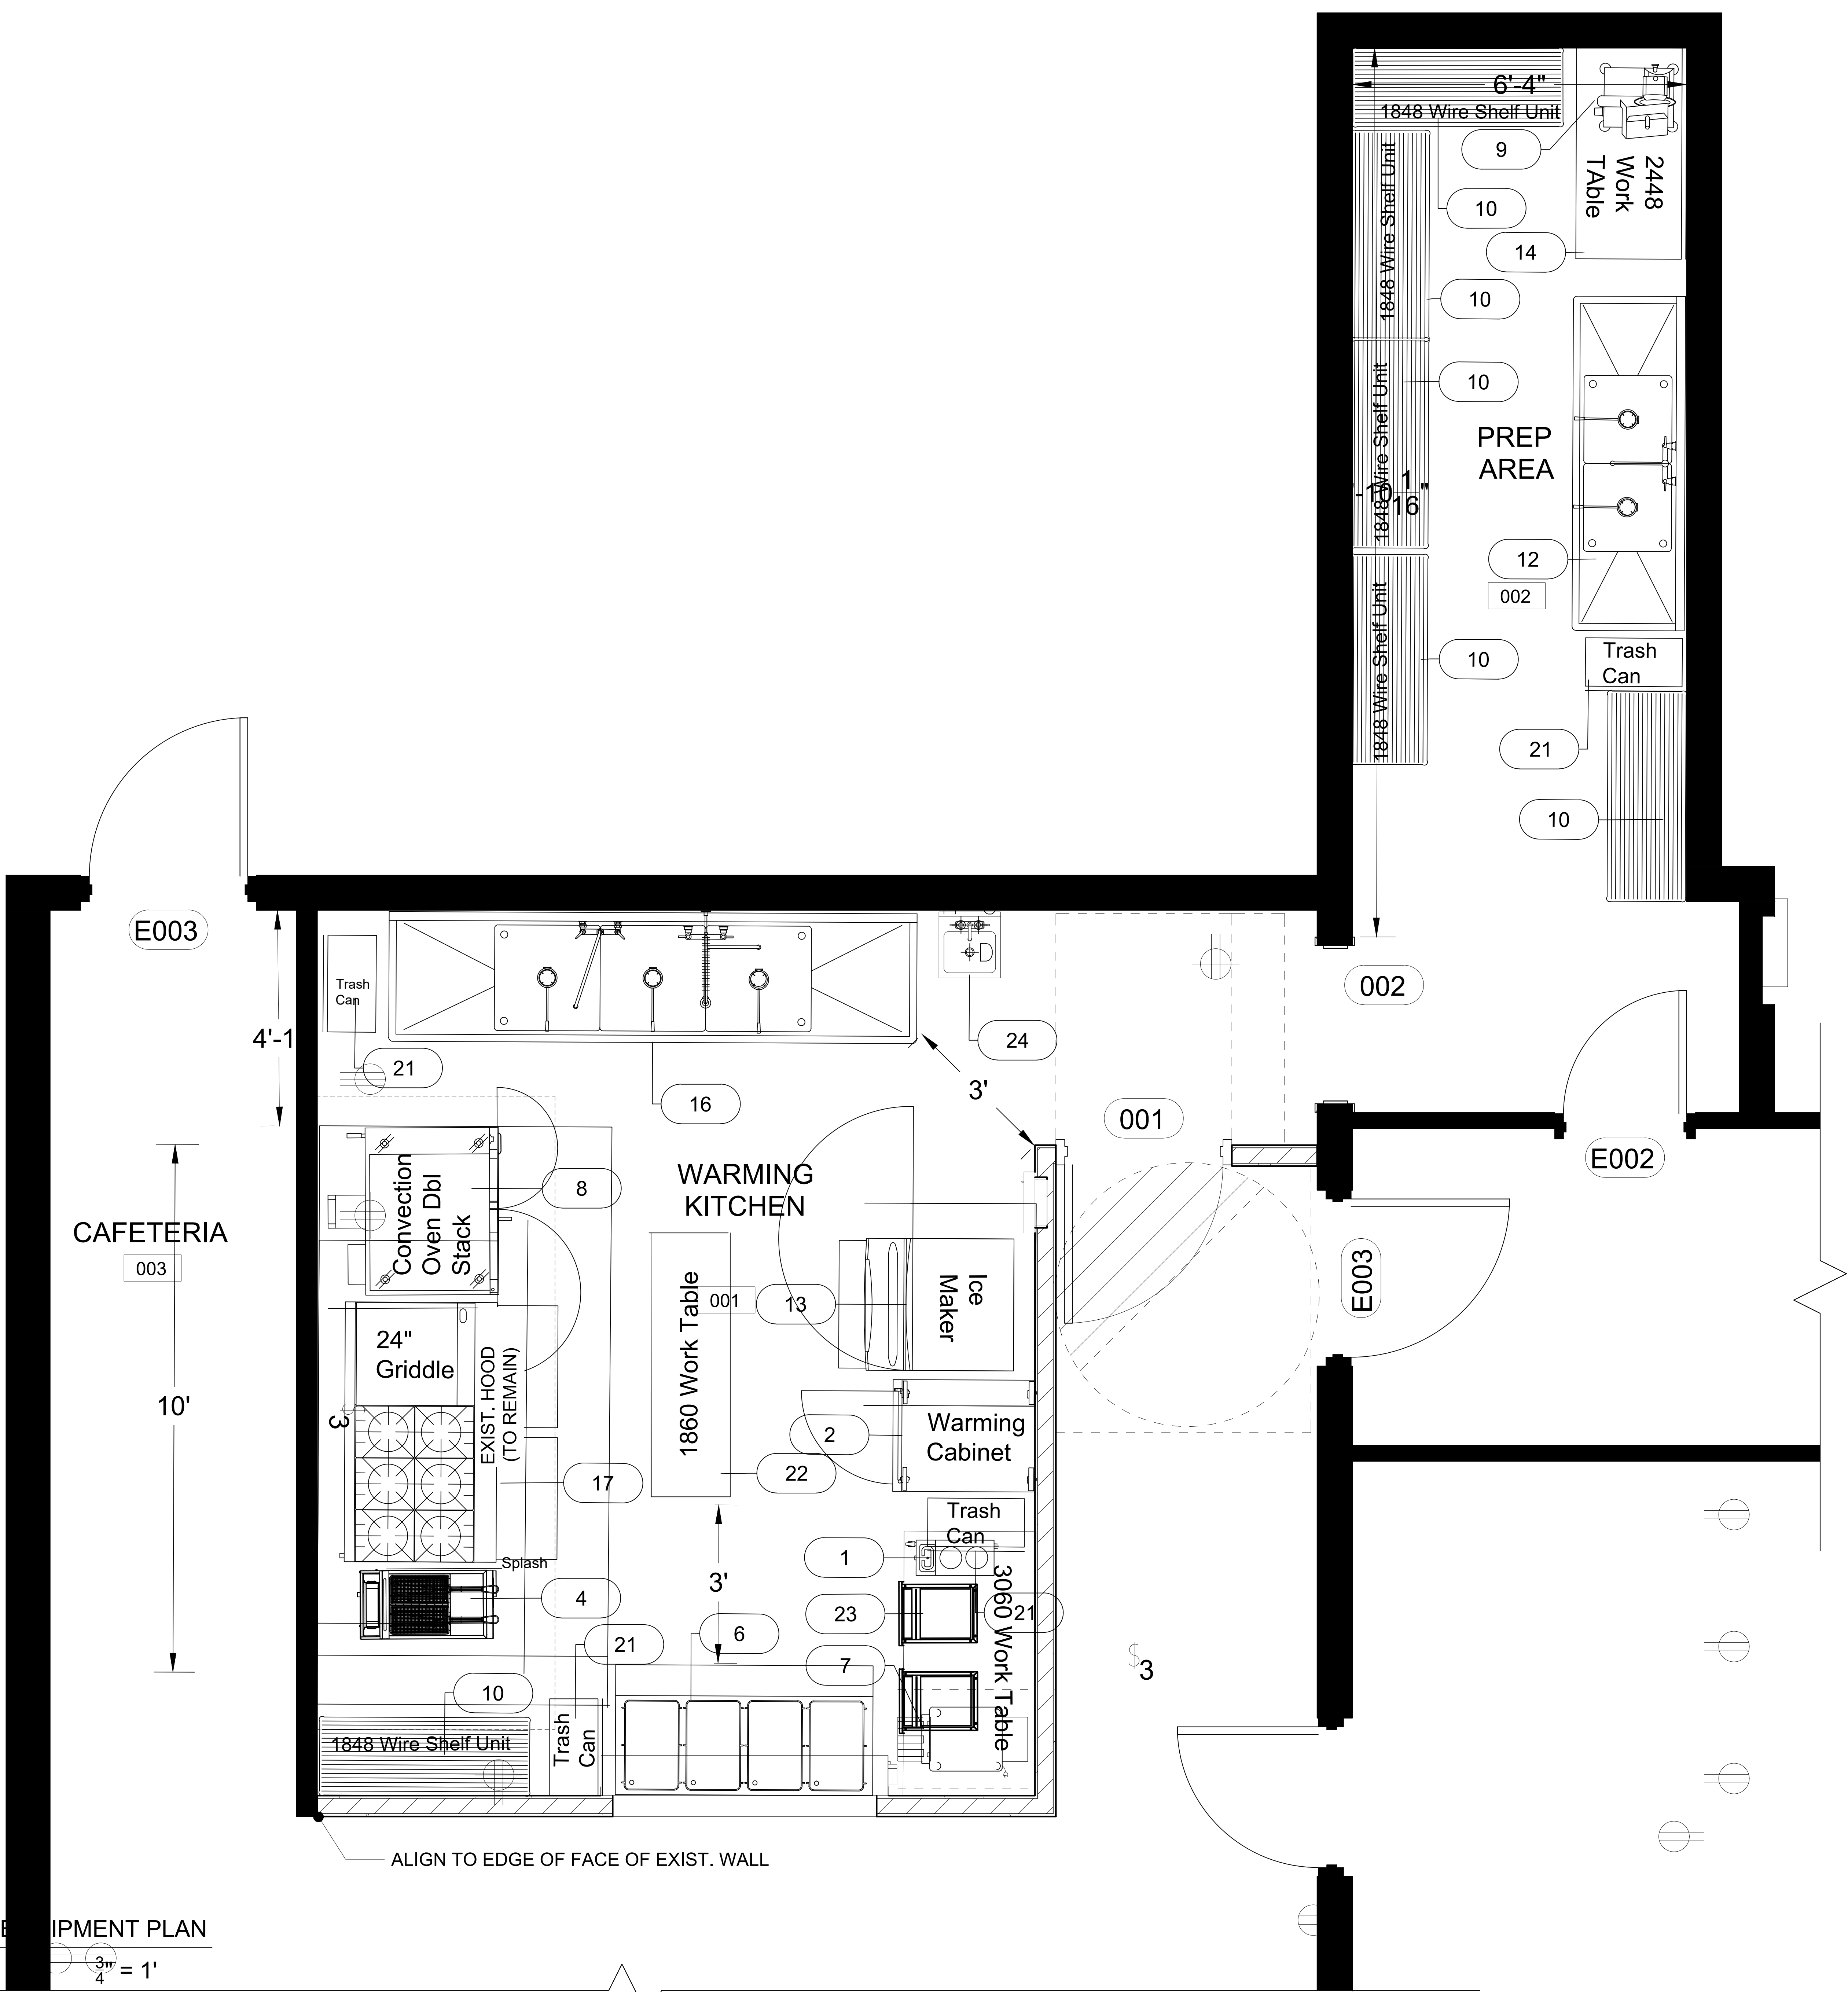

1 FOODSERVICE EQUIPMENT PLAN

3/4" = 1'

PROJECT NAME & ADDRESS:
SAMARITAN HOUSE
1580 MIDDLETON ST.
ORANGEBURG, SC 29115

**DEACON**
FOODSERVICE SOLUTIONS
SERVICE & DESIGN EXPERTS

SHEET NAME:
FOODSERVICE EQUIPMENT PLAN

DRAWN: TB

CHECKED: SD


DATE: 7/30/2026

ARCHT: AQ

SCALE: 3/4" = 1' LF

SHEET NUMBER
QF-1

REVISION	REMARKS	BY	DATE
A	Revise Range & Conv Oven to Nat Gas	TB	6/29/2026
B	Update layout & Add Prep Room	TB	7/29/2026
C	Update Floor plan to Arch Dims	TB	7/30/2026
D	Add 8" OC Faucet to 3 comp sink (2 Faucets)	TB	7/30/2026

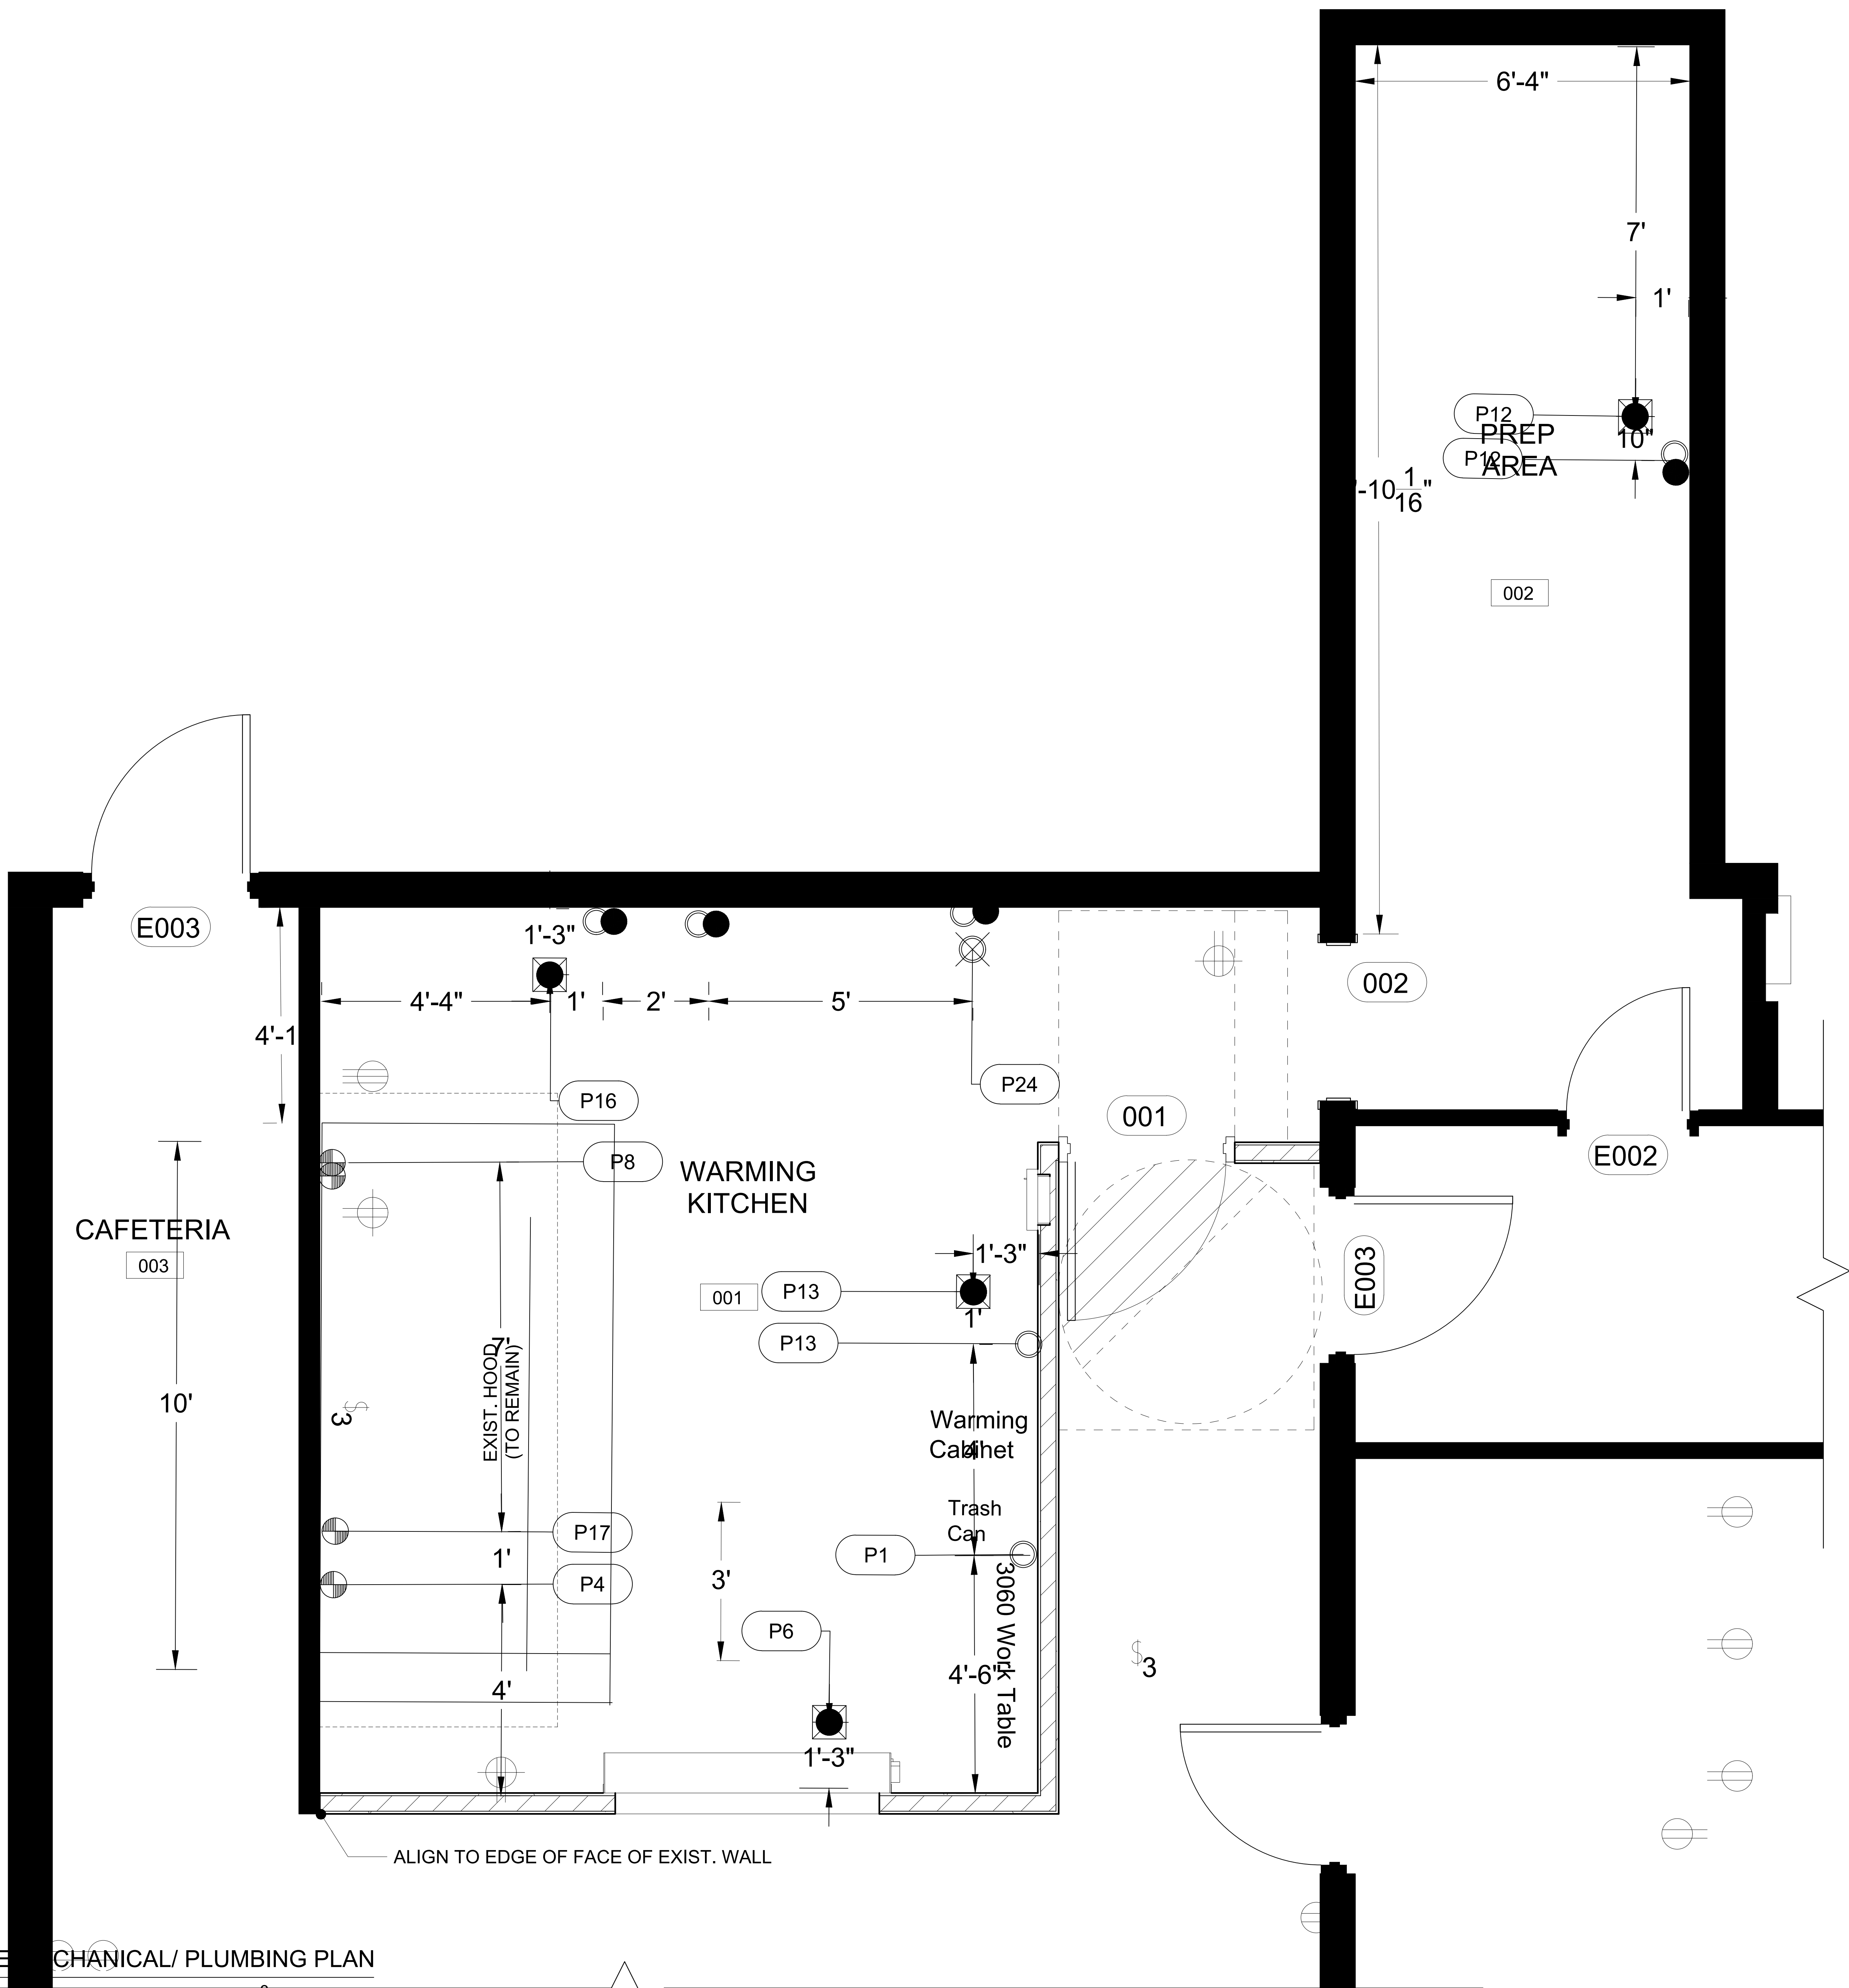

1 FOODSERVICE MECHANICAL/ PLUMBING PLAN

3/4" = 1'-0"

REVISION	REMARKS	BY	DATE
A	Revise Range & Conv Oven to Nat Gas	TB	6/29/2026
B	Update layout & Add Prep Room	TB	7/29/2026
C	Update Floor plan to Arch Dims	TB	7/30/2026
D	Add 8" OC Faucet to 3 comp sink (2 Faucets)	TB	7/30/2026

PROJECT NAME & ADDRESS:

SAMARITAN HOUSE
1580 MIDDLETON ST.
ORANGEBURG, SC 29115



SHEET NAME:

FOODSERVICE
MECH./ PLUMB.
PLAN & DETAILS

DRAWN:
TB

CHECKED:
SD


DATE:
7/30/2026



ARCH:
AQ

SCALE:
3/4" = 1LF

SHEET NUMBER

QF-2

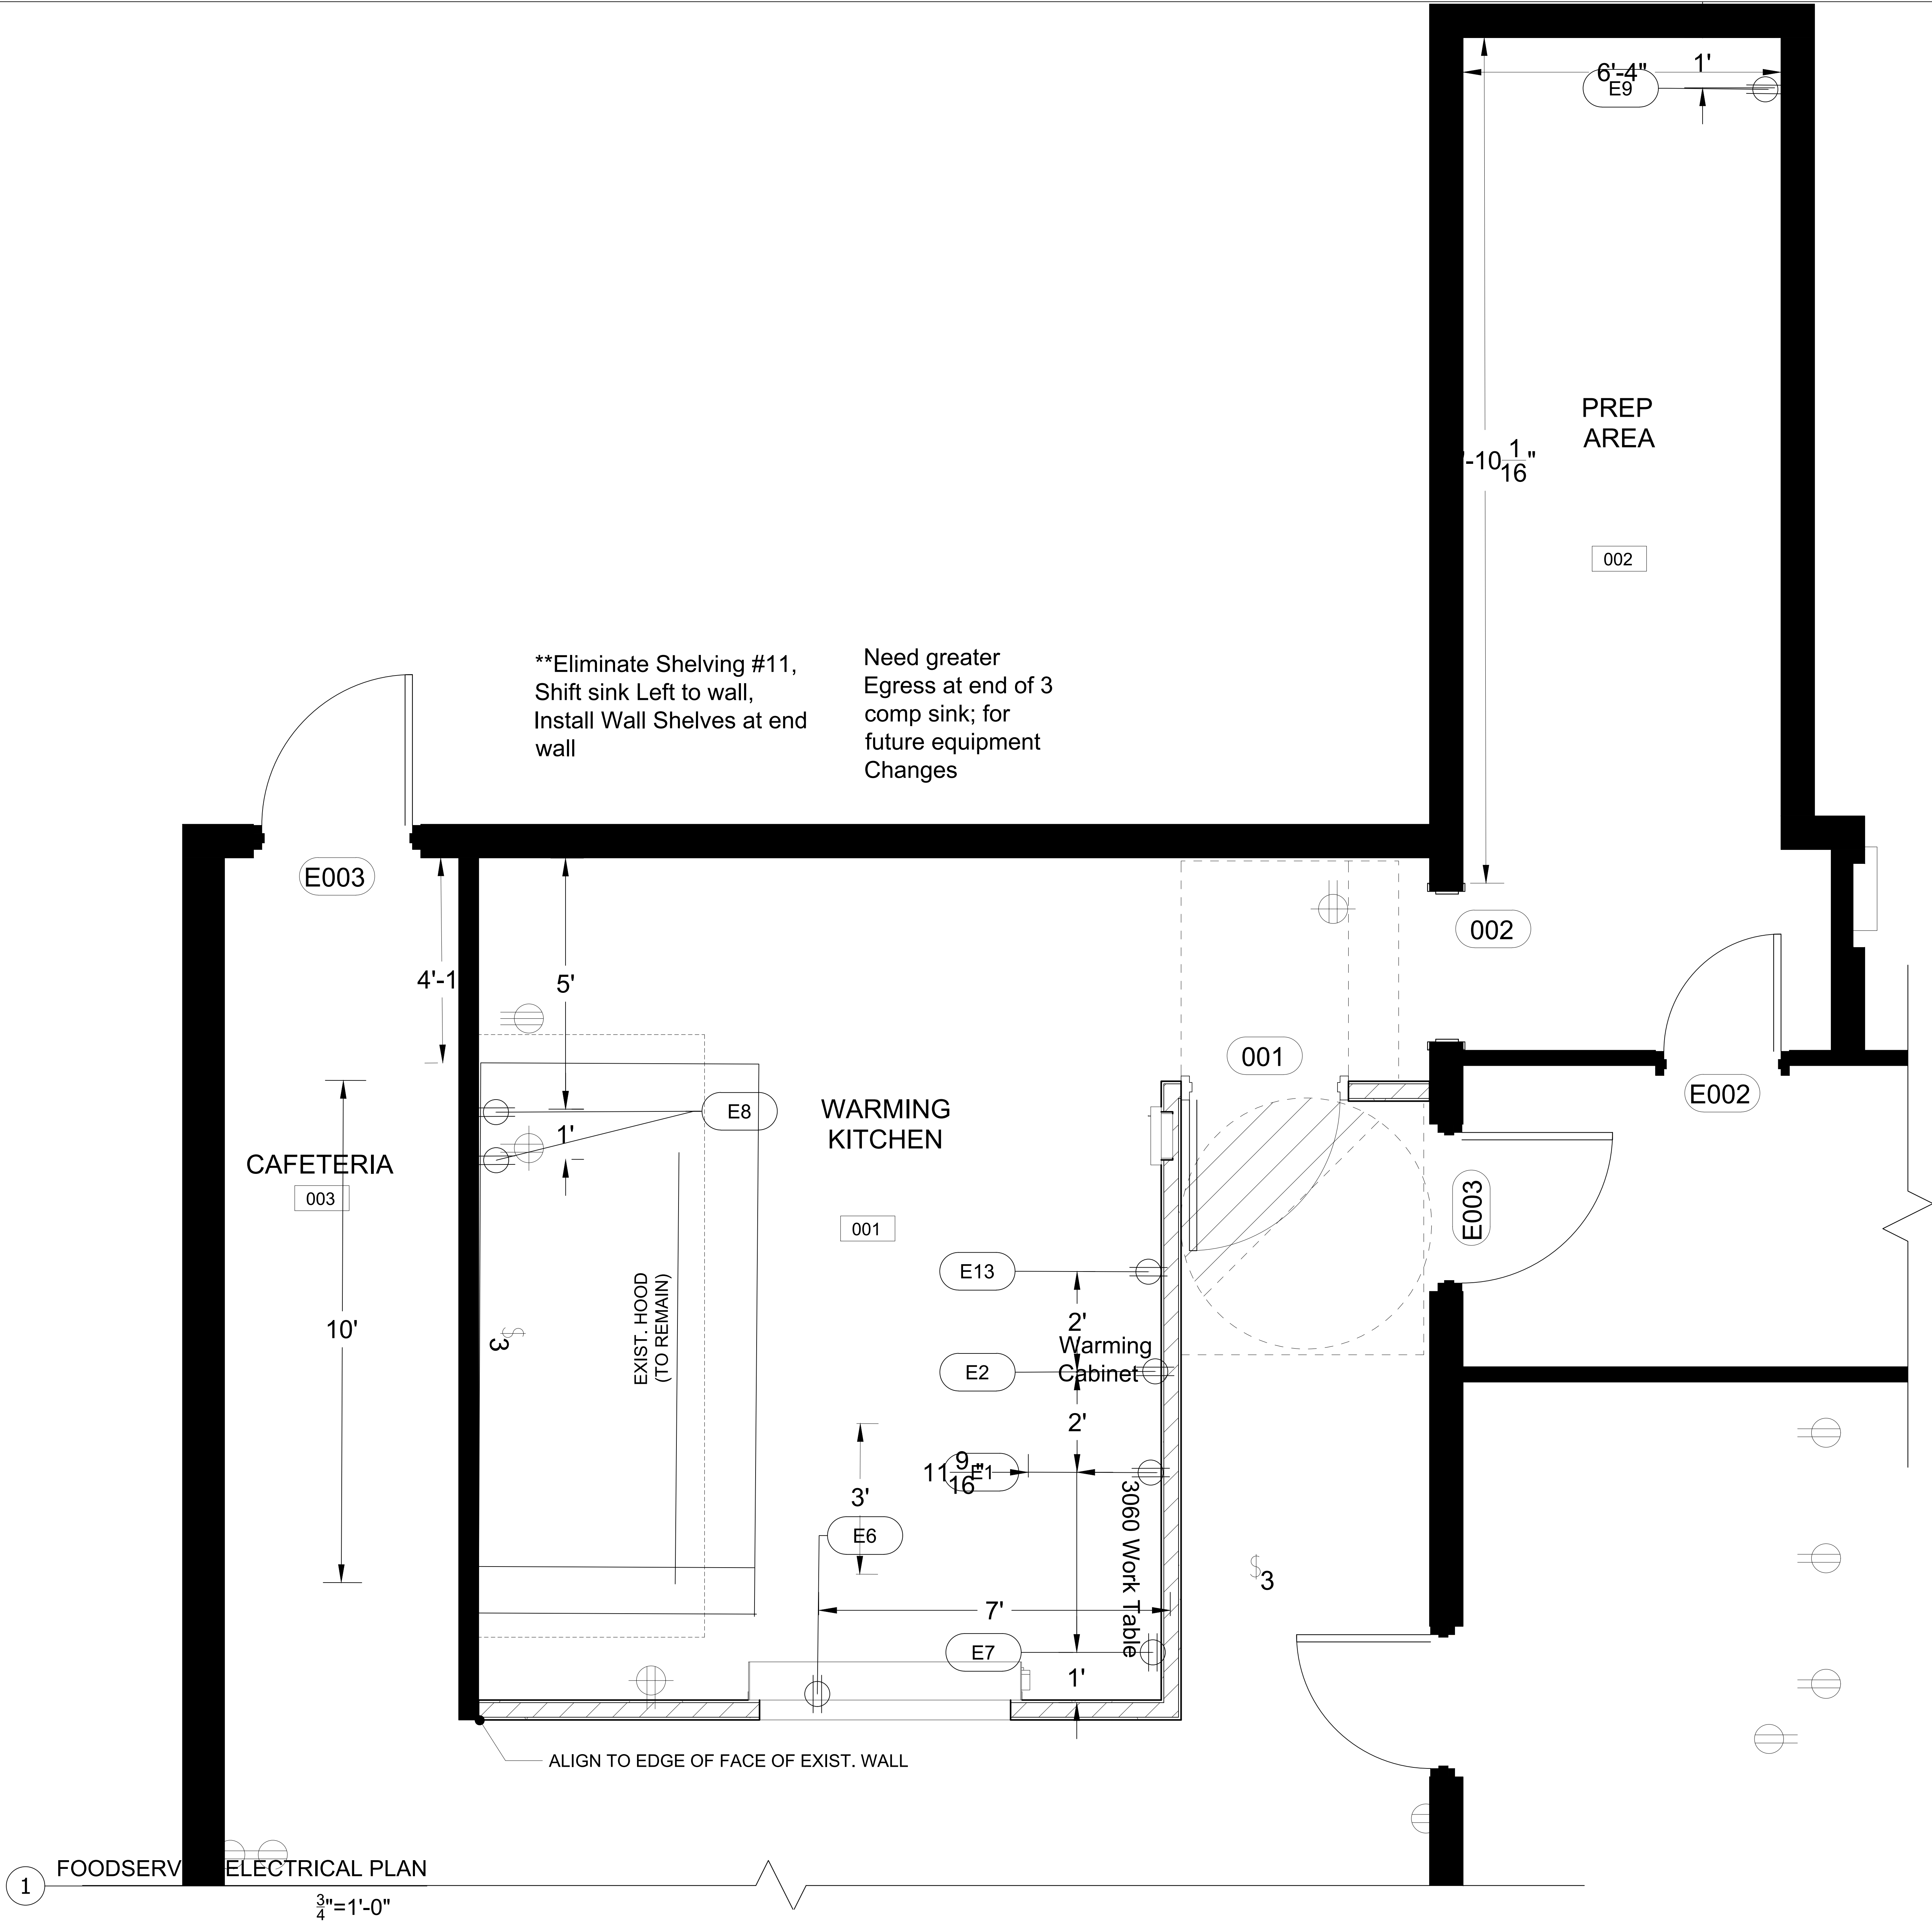

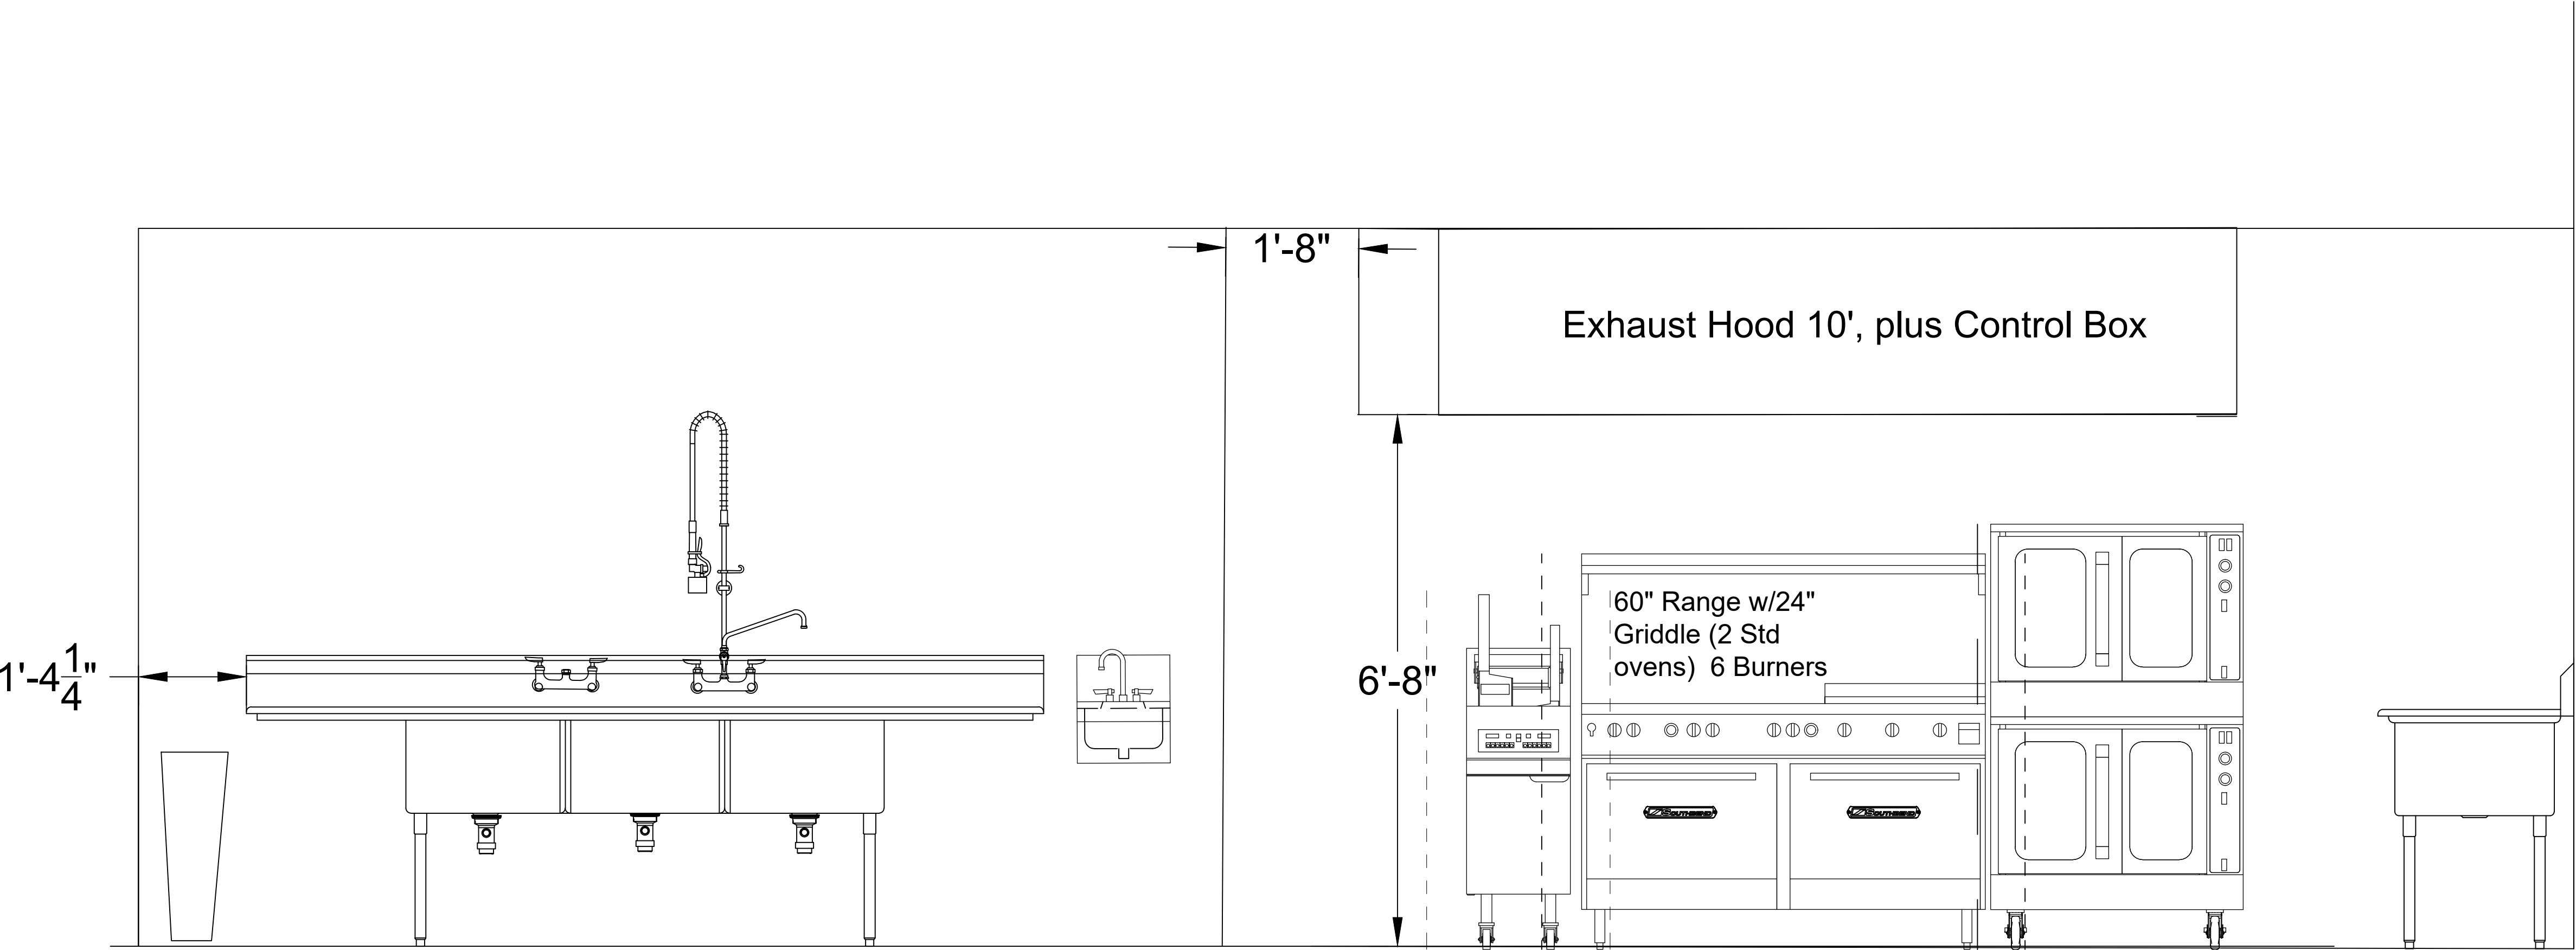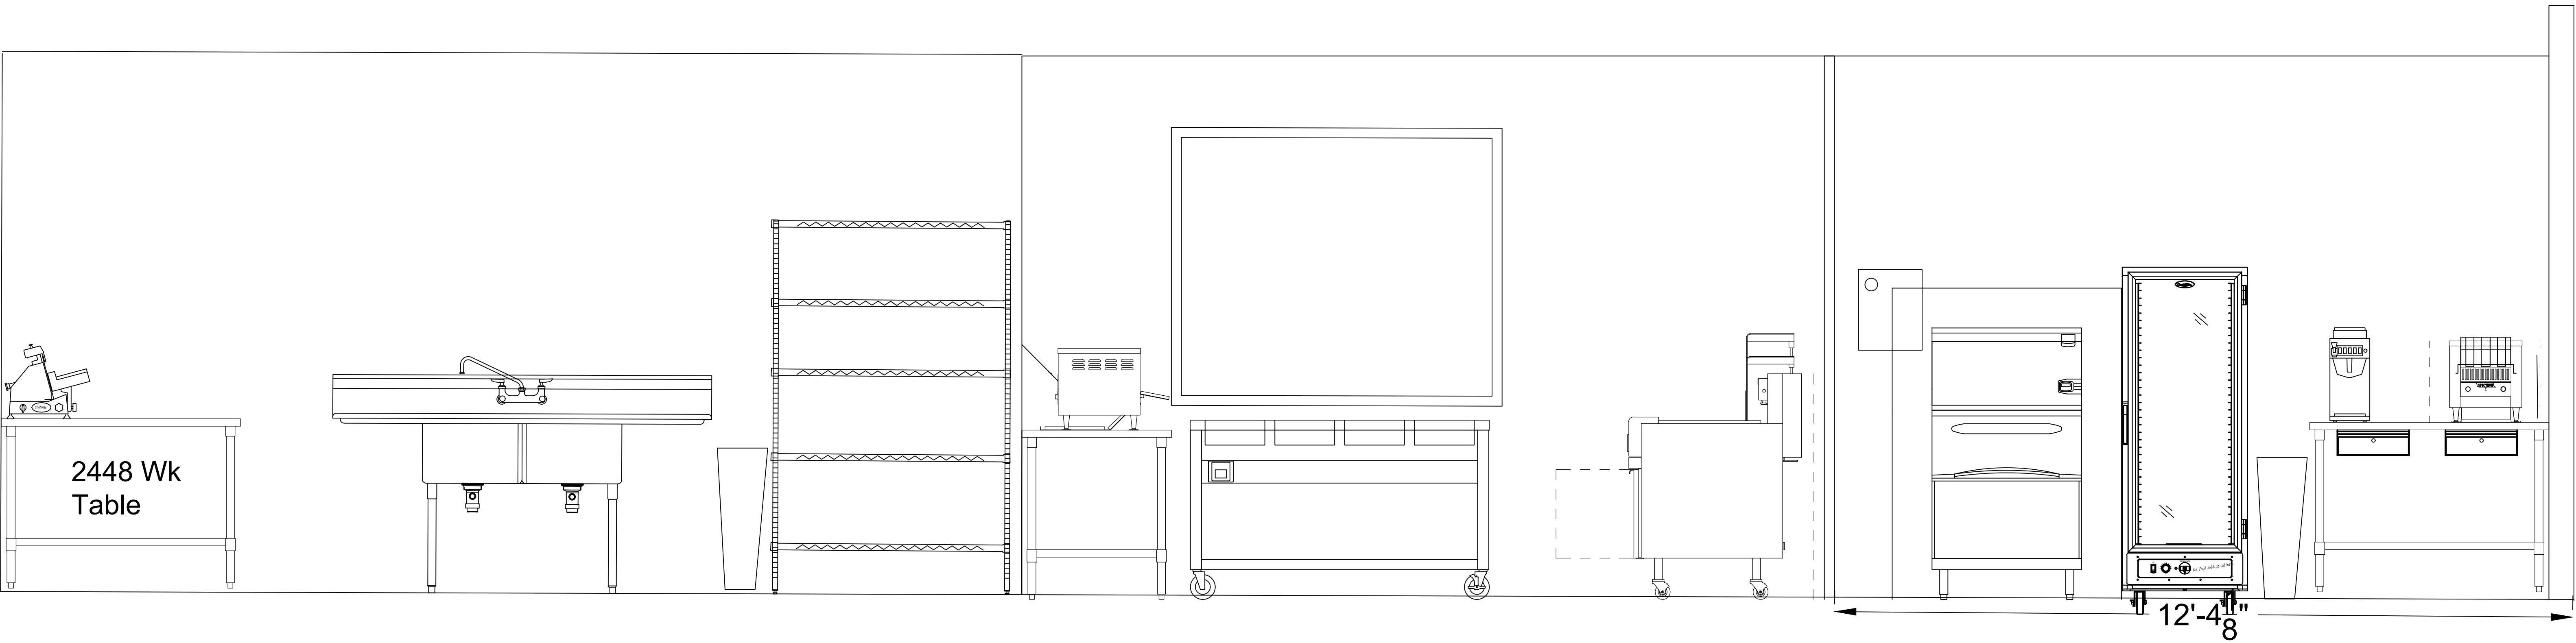

REVISION	REMARKS	BY	DATE
A	Revise Range & Conv Oven to Nat Gas	TB	6/29/2026
B	Update layout & Add Prep Room	TB	7/29/2026
C	Update Floor plan to Arch Dims	TB	7/30/2026
D	Add 8" OC Faucet to 3 comp sink (2 Faucets)	TB	7/30/2026

PROJECT NAME & ADDRESS:

SAMARITAN HOUSE
1580 MIDDLETON ST.
ORANGEBURG, SC 29115

DEACON
Since 1972
FOODSERVICE SOLUTIONS
SERVICE & DESIGN EXPERTS

SHEET NAME: FOODSERVICE EQUIPMENT DETAILS & ELEVATIONS	
DRAWN: TB	CHECKED: SD
DATE: 05/18/2026	ARCHT: AQ
SCALE: CUSTOM	
SHEET NUMBER	

EQUIPMENT SCHEDULE																											
							ELECTRICAL									PLUMBING											
ItemNo	Quantity	Unit	Category	Mfr	Model	StockModel	Voltage	Phase	Amps	Cycle	Hp	Kw	ConnectionType	NEMA	ElectricalConnection Height	Cold Water (in)	Cold Water Conn. Height(in)	Hot Water (in)	Hot Water Conn. Height(in)	Indirect Waste Size	Direct Waste Size	Direct Waste Conn. Height(in)	Gas Size(in)	GasConn.Height(I n)	Gas MBTU	Special	Equipment Remarks
1	1	ea	Coffee Brewer	BUNN	BY OWNER		120	1	14	60		1.67		5-15P	48" AFF	1/4"											
2	1	ea	Proofer Cabinet, Mobile	Winholt	BY OWNER		120	1	14	60		1.44	Cord & Plug	5-15P	14"AFF												
4	1	ea	Gas Floor Fryer	Atosa USA, Inc.	ATFS-40ES-NG																		3/4"	12"	66		
6	1	ea	Hot Food Serving Counter / Table	Atosa USA, Inc.	BY OWNER		120	1	16.7	60		2	Cord & Plug	5-20P	14"AFF												
7	1	ea	Conveyor Toaster	Winco	BY OWNER		120	1	16	60		1.8		5-15P	48" AFF												
8	1	ea	Convection Oven, Gas	Southbend (Middleby)	*EXISTING PCG100S/SD		120	1	7.9	60	1/2		Cord & Plug	5-15P									3/4"	12"	50		
	1	ea		Southbend (Middleby)	*EXISTING PCG100S/SD		120	1	7.9	60	1/2		Cord & Plug	5-15P									3/4"	12"	50		
	2	kt		T&S Brass	HG-4D-48K		120	1	7.9	60			Cord & Plug	5-15P													
	1			Southbend (Middleby)			120	1	7.9	50			Cord & Plug	5-15P													
9	1	ea	Food Slicer, Electric	By Owner	C9		115	1	2.0	60	1/4		Cord & Plug	5-15P	48" AFF												
10	30	ea	Shelving, Wire	Quantum	1848C																						
12	1	ea	Two (2) Compartment Sink	NBR Equipment	2SG-202012LR1 8																						
	1	ea		NBR Equipment	2SG-202012LR1 8																						
	1	ea		T&S Brass	B-0231-02											1/2"	12" AFF	1/2"	12" AFF								
	2	ea		T&S Brass	B-3970															1-1/2" to 2"							
16	1	ea	Three (3) Compartment Sink	NBR Equipment	3SG-242414LR2 4																						
	1	ea		NBR Equipment	3SG-242414LR2 4																						
	1	ea		NBR Equipment	3SG-242414LR2 4																						
	1	ea		T&S Brass	B-0133-12-CR-B											1/2"	12" AFF	1/2"	12" AFF								
	3	ea		T&S Brass	B-3970															1-1/2" to 2"							
17	1	ea	Range, 60" 6 Open Burners, 24" Griddle	Supera	PR10-G24-N-C																		3/4"	12"	280.0		4.5" WC
22	1	ea	Work Table, Stainless Steel Top	BK Resources	SVTR-1860																						
21	3	ea	Trash Receptacle, Indoor	By Owner	FG354060BLA																						
23	1	ea	Work Table, Stainless Steel Top	Atosa USA, Inc.	SSTW-3060																						
24	1	ea	Hand Sink	Serv-Ware	HS10S-CWP											1/2"	24"	1/2"	24"			1-1/2"					

REVISION	REMARKS	BY	DATE
A	Revise Range & Conv Oven to Nat Gas	TB	6/29/2026
B	Update layout & Add Prep Room	TB	7/29/2026
C	Update Floor plan to Arch Dims	TB	7/30/2026
D	Add 8" OC Faucet to 3 comp sink (2 Faucets)	TB	7/30/2026

PROJECT NAME & ADDRESS:

SAMARITAN HOUSE
1580 MIDDLETON ST.
ORANGEBURG, SC 29115

DEACON

SinceFOODSERVICE1972

SOLUTIONS

SERVICE & DESIGN EXPERTS

SHEET NAME:

FOODSERVICE
UTILITY
SCHEDULE

DRAWN:
TB

CHECKED:
SD

DATE:
05/18/2026

ARCH:
AQ

SCALE:
N/A

SHEET NUMBER

QF-6