

Autodesk Docs\03250472B0-USC North Energy Plant Chiller 2 Replacement\03250472 B0_MEP_22.rvt 6/8/2026 2:33:59 PM

H
G
F
E
D
C
B
A

8 7 6 5 4 3 2 1



UNIVERSITY OF
SOUTH CAROLINA

CHILLER AND INFRASTRUCTURE REPLACEMENT - NORTH CH#2

BID DOCUMENTS

June 12, 2026

Client Project No. H27-Z621 50003714


RMF Project No. : 03250472.B0

DESIGN TEAM



RMF ENGINEERING, INC.
194 SEVEN FARM DRIVE
SUITE G
CHARLESTON, SC 29492
P: 843-971-9639 F: 843-971-9641


SITE MAP

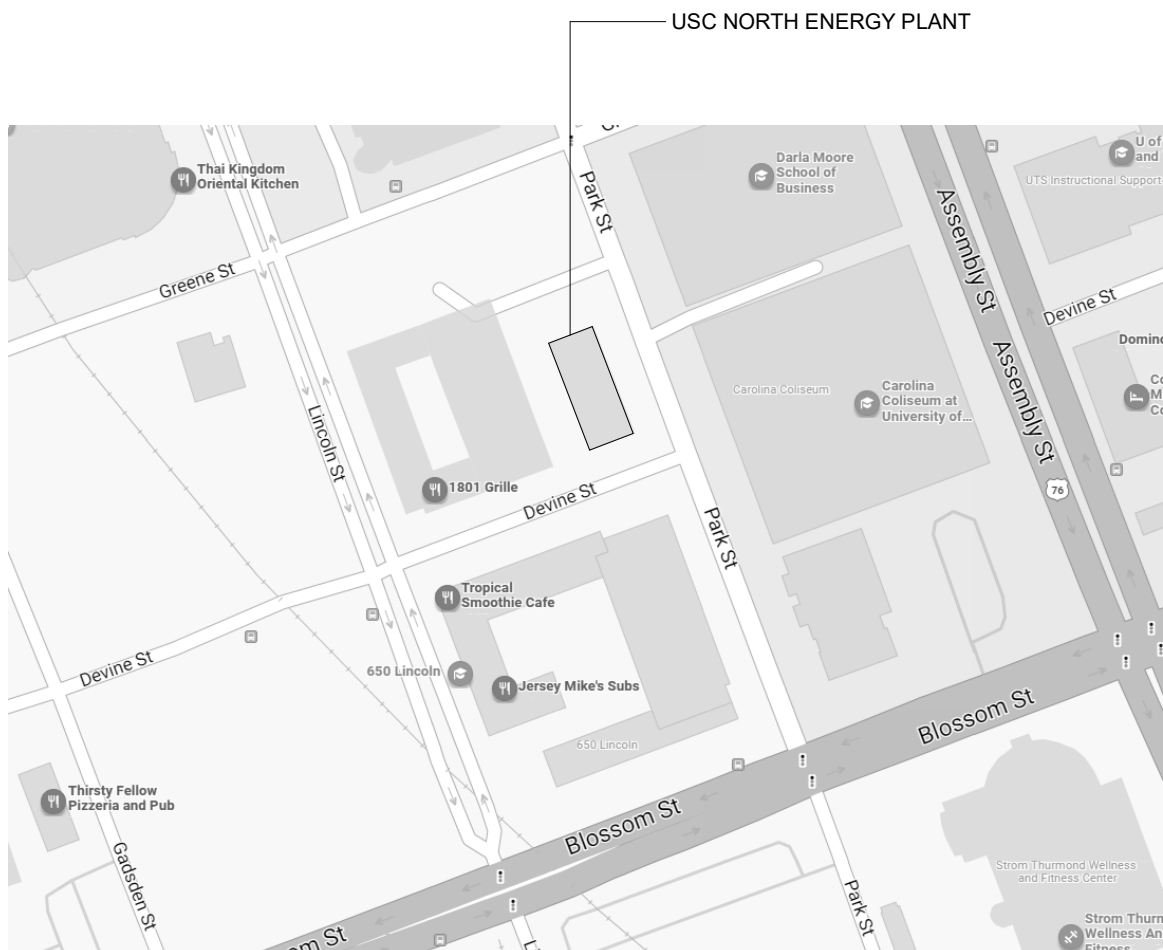

DRAWING INDEX

T-000	TITLE SHEET
M-001	MECHANICAL NOTES, SYMBOLS AND ABBREVIATIONS
M-002	SITE PLAN
MD-101	MECHANICAL - DEMOLITION
M-101	MECHANICAL - NEW WORK
M-301	CHILLED WATER SCHEMATIC - DEMOLITION
M-302	CHILLED WATER SCHEMATIC
M-303	TOWER WATER SCHEMATIC - DEMOLITION
M-304	TOWER WATER SCHEMATIC
M-305	MECHANICAL INPUT/OUTPUT SUMMARY AND SEQUENCE OF OPERATIONS
E-001	ELECTRICAL NOTES, SYMBOLS AND ABBREVIATIONS
E-002	ELECTRICAL NOTES, SYMBOLS, AND ABBREVIATIONS
ED-101	ELECTRICAL - DEMOLITION
E-101	ELECTRICAL - NEW WORK
E-700	ELECTRICAL PARTIAL ONE-LINE DIAGRAM - DEMOLITION
E-701	ELECTRICAL PARTIAL ONE-LINE DIAGRAM - NEW WORK

AREA MAP

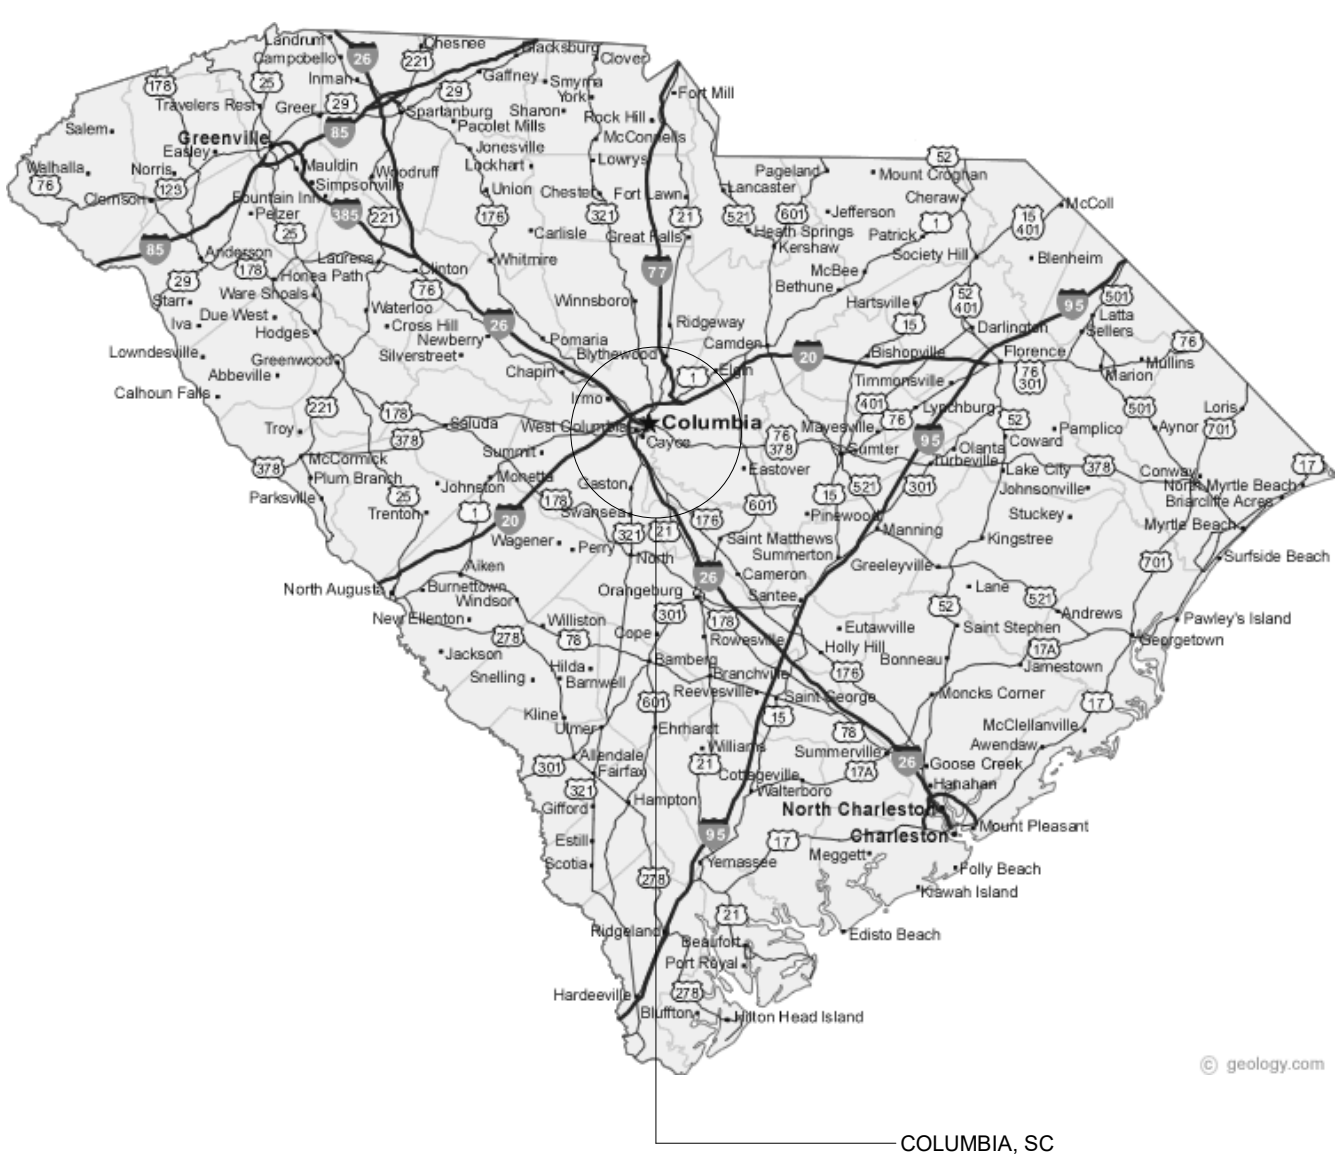

RMF ENGINEERING, INC.
194 SEVEN FARM DRIVE
SUITE G
CHARLESTON, SC 29492
P: 843-971-9639 F: 843-971-9641



UNIVERSITY OF
SOUTH CAROLINA

REV	DESCRIPTION	DATE

REV	DESCRIPTION	DATE

SUBMISSION TITLE :
Bid Documents

THIS DRAWING AND ALL COPIES THEREOF IS THE PROPERTY OF RMF ENGINEERING, INC. THIS DRAWING MAY NOT BE USED OR REPRODUCED WITHOUT THE WRITTEN CONSENT OF RMF ENGINEERING, INC.

SEAL:

DRAWN BY: KJA DATE: 06/12/2026
DESIGNED BY: KJA SCALE: NONE
CHECKED BY: SOD RMF JOB NO.: 03250472.B0
PROJ. MGR.: DWZ CLIENT JOB #: H27-Z621 50003714

PROJECT NAME :
CHILLER AND
INFRASTRUCTURE
REPLACEMENT - NORTH
CH#2

PROJECT ADDRESS :
701 Park St, Columbia, SC
29208

DRAWING TITLE :
TITLE SHEET


DRAWING NUMBER :
T-000

H
G
F
E
D
C
B
A

8 7 6 5 4 3 2 1



RMF ENGINEERING, INC.
194 SEVEN FARM DRIVE
SUITE G
CHARLESTON, SC 29492
P: 843-971-9639 F: 843-971-9641

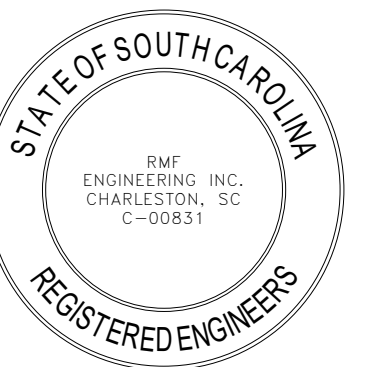

REV	DESCRIPTION	DATE
REVISIONS		

SUBMISSION TITLE :
Bid Documents

THIS DRAWING AND ALL COPIES THEREOF IS THE PROPERTY OF RMF
ENGINEERING, INC. THIS DRAWING MAY NOT BE USED OR REPRODUCED
WITHIN ANY COMPUTER ENVIRONMENT OR BY ANY PRINT MEDIA
FORMAT WITHOUT THE WRITTEN CONSENT OF RMF ENGINEERING, INC.

EAL:

DRAWN BY: KJA	DATE: 06/12/2026
DESIGNED BY: KJA	SCALE: 1/8" = 1'-0"
CHECKED BY: SOD	RMF JOB NO.: 03250472.B0
ROJ. MGR.: DWZ	CLIENT JOB #: H27-Z621 50003714

PROJECT NAME :
CHILLER AND
INFRASTRUCTURE
REPLACEMENT - NORTH
CH#2

PROJECT ADDRESS :
701 Park St, Columbia, SC
29208

DRAWING TITLE :
SITE PLAN

DRAWING NUMBER :

M-002

GENERAL NOTES

1. DRAWING IS PROVIDED FOR GENERAL CONSTRUCTION LAYDOWN AND STAGING AREA. CONTRACTOR SHALL COORDINATE CRANE LOCATION AND LIFTS AS REQUIRED.
2. CONTRACTOR SHALL SUBMIT TO THE ENGINEER AND OWNER APPROVED CONSTRUCTION SCHEDULE THAT INCLUDES CRANE LIFTS AND CRANE LOCATIONS.

DRAWING NOTES

1. CONTRACTOR LAYDOWN AREA.

NORTH



KEY PLAN



25' 0 25' 50'



SCALE: 1" = 50'-0"

SITE PLAN
SCALE: 1" = 50'-0"

Autodesk Docs://03250472B0-USC North Energy Plant Chiller 2 Replacement/03250472.B0_MEP_22.rvt

6/12/2026 10:36:30 AM

Autodesk Docs/03250472B0-USC North Energy Plant Chiller 2 Replacement/03250472 B0_MEP_22.rvt

6/12/2026 10:36:38 AM

MECHANICAL - LOWER LEVEL - DEMOLITION
SCALE: 1/8" = 1'-0"

MECHANICAL - UPPER LEVEL - DEMOLITION
SCALE: 1/8" = 1'-0"

GENERAL NOTES


1. REMOVE COMPLETELY THE EXISTING CHILLER AND ALL ASSOCIATED ELECTRICAL CONNECTIONS.
2. EXISTING EQUIPMENT PAD SHALL BE REUSED FOR NEW CHILLER.

DRAWING NOTES

1. CLOSE MANUAL BUTTERFLY VALVE TO ISOLATE CHILLER FOR THE REMOVAL OF THE EXISTING CHILLER AND INSTALLATION OF THE NEW CHILLER.
2. THE CHILLED WATER SYSTEM SHALL BE SHUT DOWN FOR THE DEMOLITION OF CHILLER CH-2 AND THE DEMOLITION OF THE ASSOCIATED CHILLED WATER BRANCHES. DEMOLISH BRANCHES BACK TO THE PIPE MAIN AND PATCH PIPE MAIN PIPING.
3. THE TOWER WATER SYSTEM SHALL BE SHUT DOWN FOR THE DEMOLITION OF CHILLER CH-2 AND THE DEMOLITION OF THE ASSOCIATED TOWER WATER BRANCHES. DEMOLISH BRANCHES BACK TO THE PIPE MAIN AND PATCH PIPE MAIN PIPING.
4. DEMOLISH EXISTING CHILLER 2 REFRIGERANT LEAK DETECTION MONITOR. PREPARE EXISTING POWER AND CONTROLS CONNECTION FOR NEW MONITOR CONNECTION.
5. DEMOLISH EXISTING CHILLER 2 REFRIGERANT LEAK DETECTION MONITOR PANEL. PREPARE EXISTING POWER AND CONTROLS CONNECTION FOR NEW PANEL CONNECTION.
6. DEMOLISH REFRIGERANT VENT PIPING AND PATCH ROOF PENETRATION. MATERIAL SHALL MATCH ADJACENT EXISTING ROOF MATERIALS.



RMF ENGINEERING, INC.
194 SEVEN FARM DRIVE
SUITE G
CHARLESTON, SC 29492
P: 843-971-9639 F: 843-971-9641

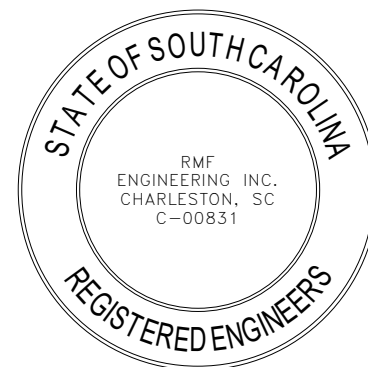

REV	DESCRIPTION	DATE
REVISIONS		

SUBMISSION TITLE:
Bid Documents

THIS DRAWING AND ALL COPIES THEREOF IS THE PROPERTY OF RMF ENGINEERING, INC. THIS DRAWING MAY NOT BE USED OR REPRODUCED WITHOUT ANY COMPUTER EQUIPMENT OR BY ANY PHOTO MEANS, WITHOUT THE WRITTEN CONSENT OF RMF ENGINEERING, INC.

SEAL:

DRAWN BY: KJA DATE: 06/12/2026
DESIGNED BY: KJA SCALE: 1/8" = 1'-0"
CHECKED BY: SOD RMF JOB NO.: 03250472.B0
PROJ. MGR.: DWZ CLIENT JOB #: H27-2821 50003714

PROJECT NAME:
**CHILLER AND
INFRASTRUCTURE
REPLACEMENT - NORTH
CH#2**

PROJECT ADDRESS:
**701 Park St, Columbia, SC
29208**

DRAWING TITLE:
MECHANICAL - DEMOLITION

DRAWING NUMBER:

MD-101

Autodesk Docs://03250472B0-USC North Energy Plant Chiller 2 Replacement/03250472 B0_MEP_22.rvt

6/12/2026 10:36:33 AM

CHILLER SCHEDULE


DESIGNATION	TYPE	CAPACITY (TONS)	EVAPORATOR							CONDENSER							MINIMUM EFFICIENCY (KW/TON)	REFRIGERANT	ELECTRICAL							MAXIMUM DIMENSIONS (LxWxH)	OPERATING WEIGHT (LBS)	BASIS OF DESIGN	REMARKS
			GPM	MIN GPM	EWT (°F)	LWT (°F)	PASS	MAX PD (FT H2O)	FOULING FACTOR	GPM	MIN GPM	EWT (°F)	LWT (°F)	PASS	MAX PD (FT H2O)	FOULING FACTOR	FULL LOAD		VOLTS	PHASE	HERTZ	MOCP (A)	RLA (A)	MCA (A)	STARTER				
CH-02	ELECTRIC CENTRIFUGAL	3000	4,800	2535	57	42	1	64.3	0.0001	6,600	4277	85	98	1	49.2	0.0003	0.5546	R-514A	4160	3	60	460	274	343	MECHANICAL	402x143x142	112511.0	TRANE	

GENERAL NOTES


- CONNECT CHILLER TO THE EXISTING CENTRAL CONTROL AND MONITORING SYSTEM (CCMS) TO OPERATE AS THE EXISTING CHILLER DOES.

DRAWING NOTES

- CLOSE MANUAL BUTTERFLY VALVE TO ISOLATE CHILLER FOR THE REMOVAL OF THE EXISTING CHILLER AND INSTALLATION OF THE NEW CHILLER.
- THE CHILLED WATER SYSTEM SHALL BE SHUT DOWN FOR THE INSTALLATION OF THE NEW CHILLED WATER BRANCHES FOR CHILLER 2. INSTALL BRANCH TAPS TO THE MANUAL BUTTERFLY ISOLATION VALVE PRIOR TO ANY DEMOLITION WORK. COORDINATE AND SCHEDULE SHUTDOWN WITH THE OWNER.
- THE TOWER WATER SYSTEM SHALL BE SHUT DOWN FOR THE INSTALLATION OF THE NEW TOWER WATER BRANCHES FOR CHILLER 2. INSTALL BRANCH TAPS TO THE MANUAL BUTTERFLY ISOLATION VALVE PRIOR TO ANY DEMOLITION WORK. COORDINATE AND SCHEDULE SHUTDOWN WITH THE OWNER.
- CONNECT NEW REFRIGERANT LEAK DETECTION MONITOR TO EXISTING POWER AND CONTROLS CONNECTIONS. NEW REFRIGERANT LEAK DETECTION MONITOR SHALL CONNECT TO THE EXISTING BUILDING AUTOMATION SYSTEM AND OPERATE AS THE EXISTING REFRIGERANT MONITORING SYSTEM DOES.
- CONNECT NEW REFRIGERANT LEAK DETECTION MONITOR PANEL TO EXISTING POWER AND CONTROLS CONNECTIONS. NEW REFRIGERANT LEAK DETECTION MONITOR PANEL SHALL CONNECT TO THE EXISTING BUILDING AUTOMATION SYSTEM AND OPERATE AS THE EXISTING REFRIGERANT MONITORING SYSTEM PANEL DOES.

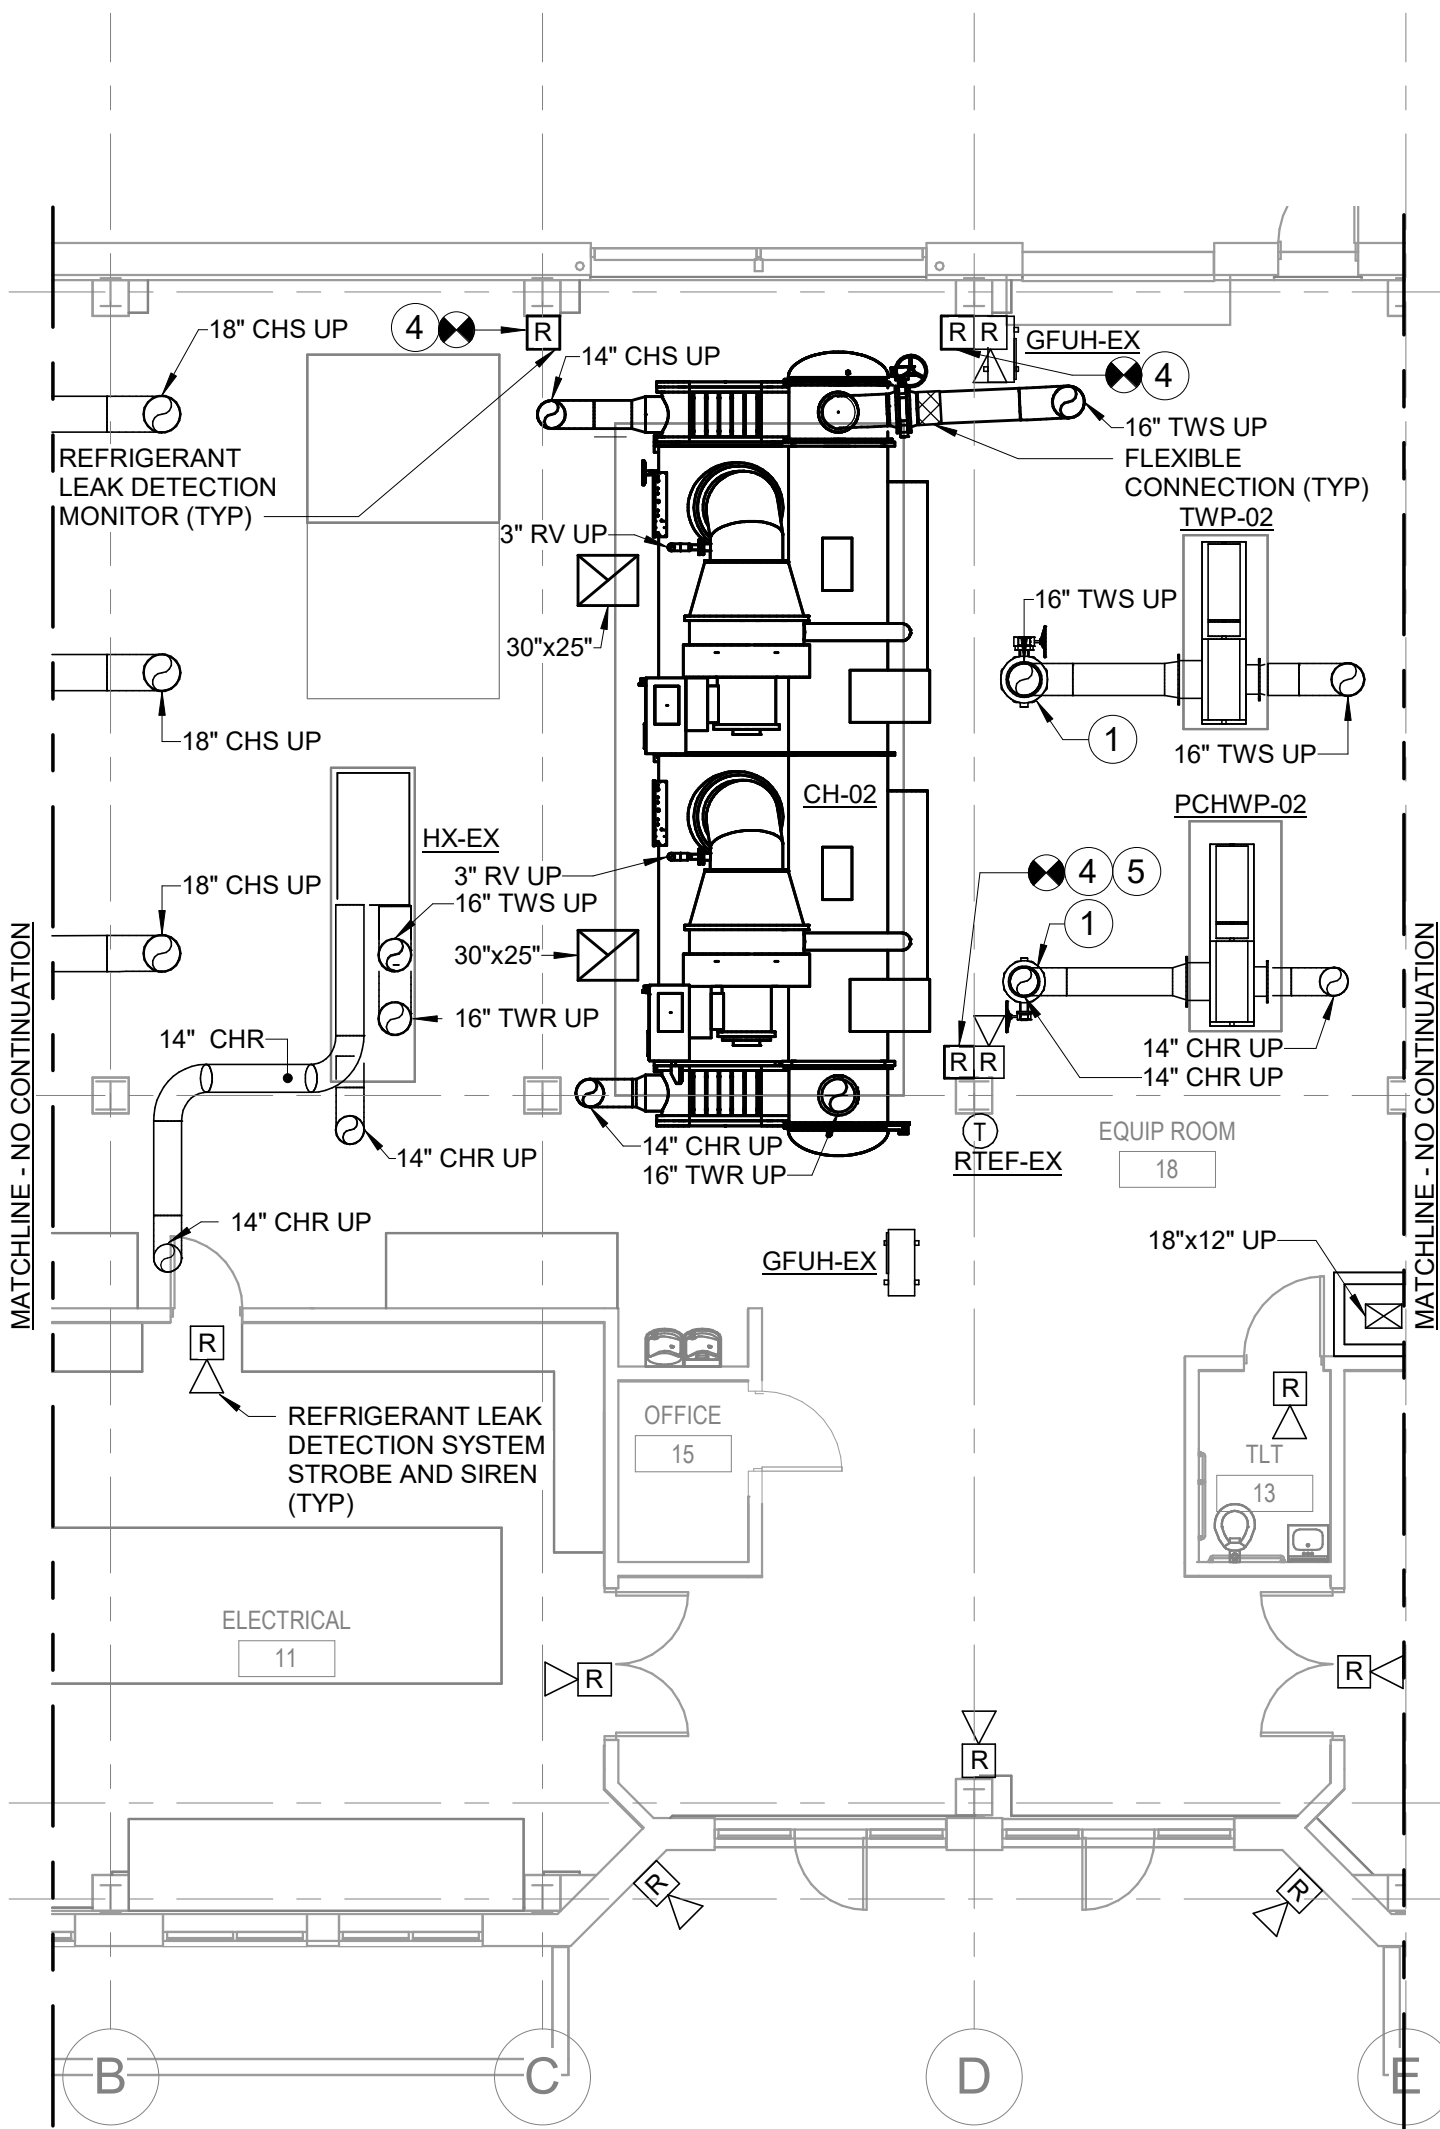


MECHANICAL - LOWER LEVEL - NEW WORK
SCALE: 1/8" = 1'-0"

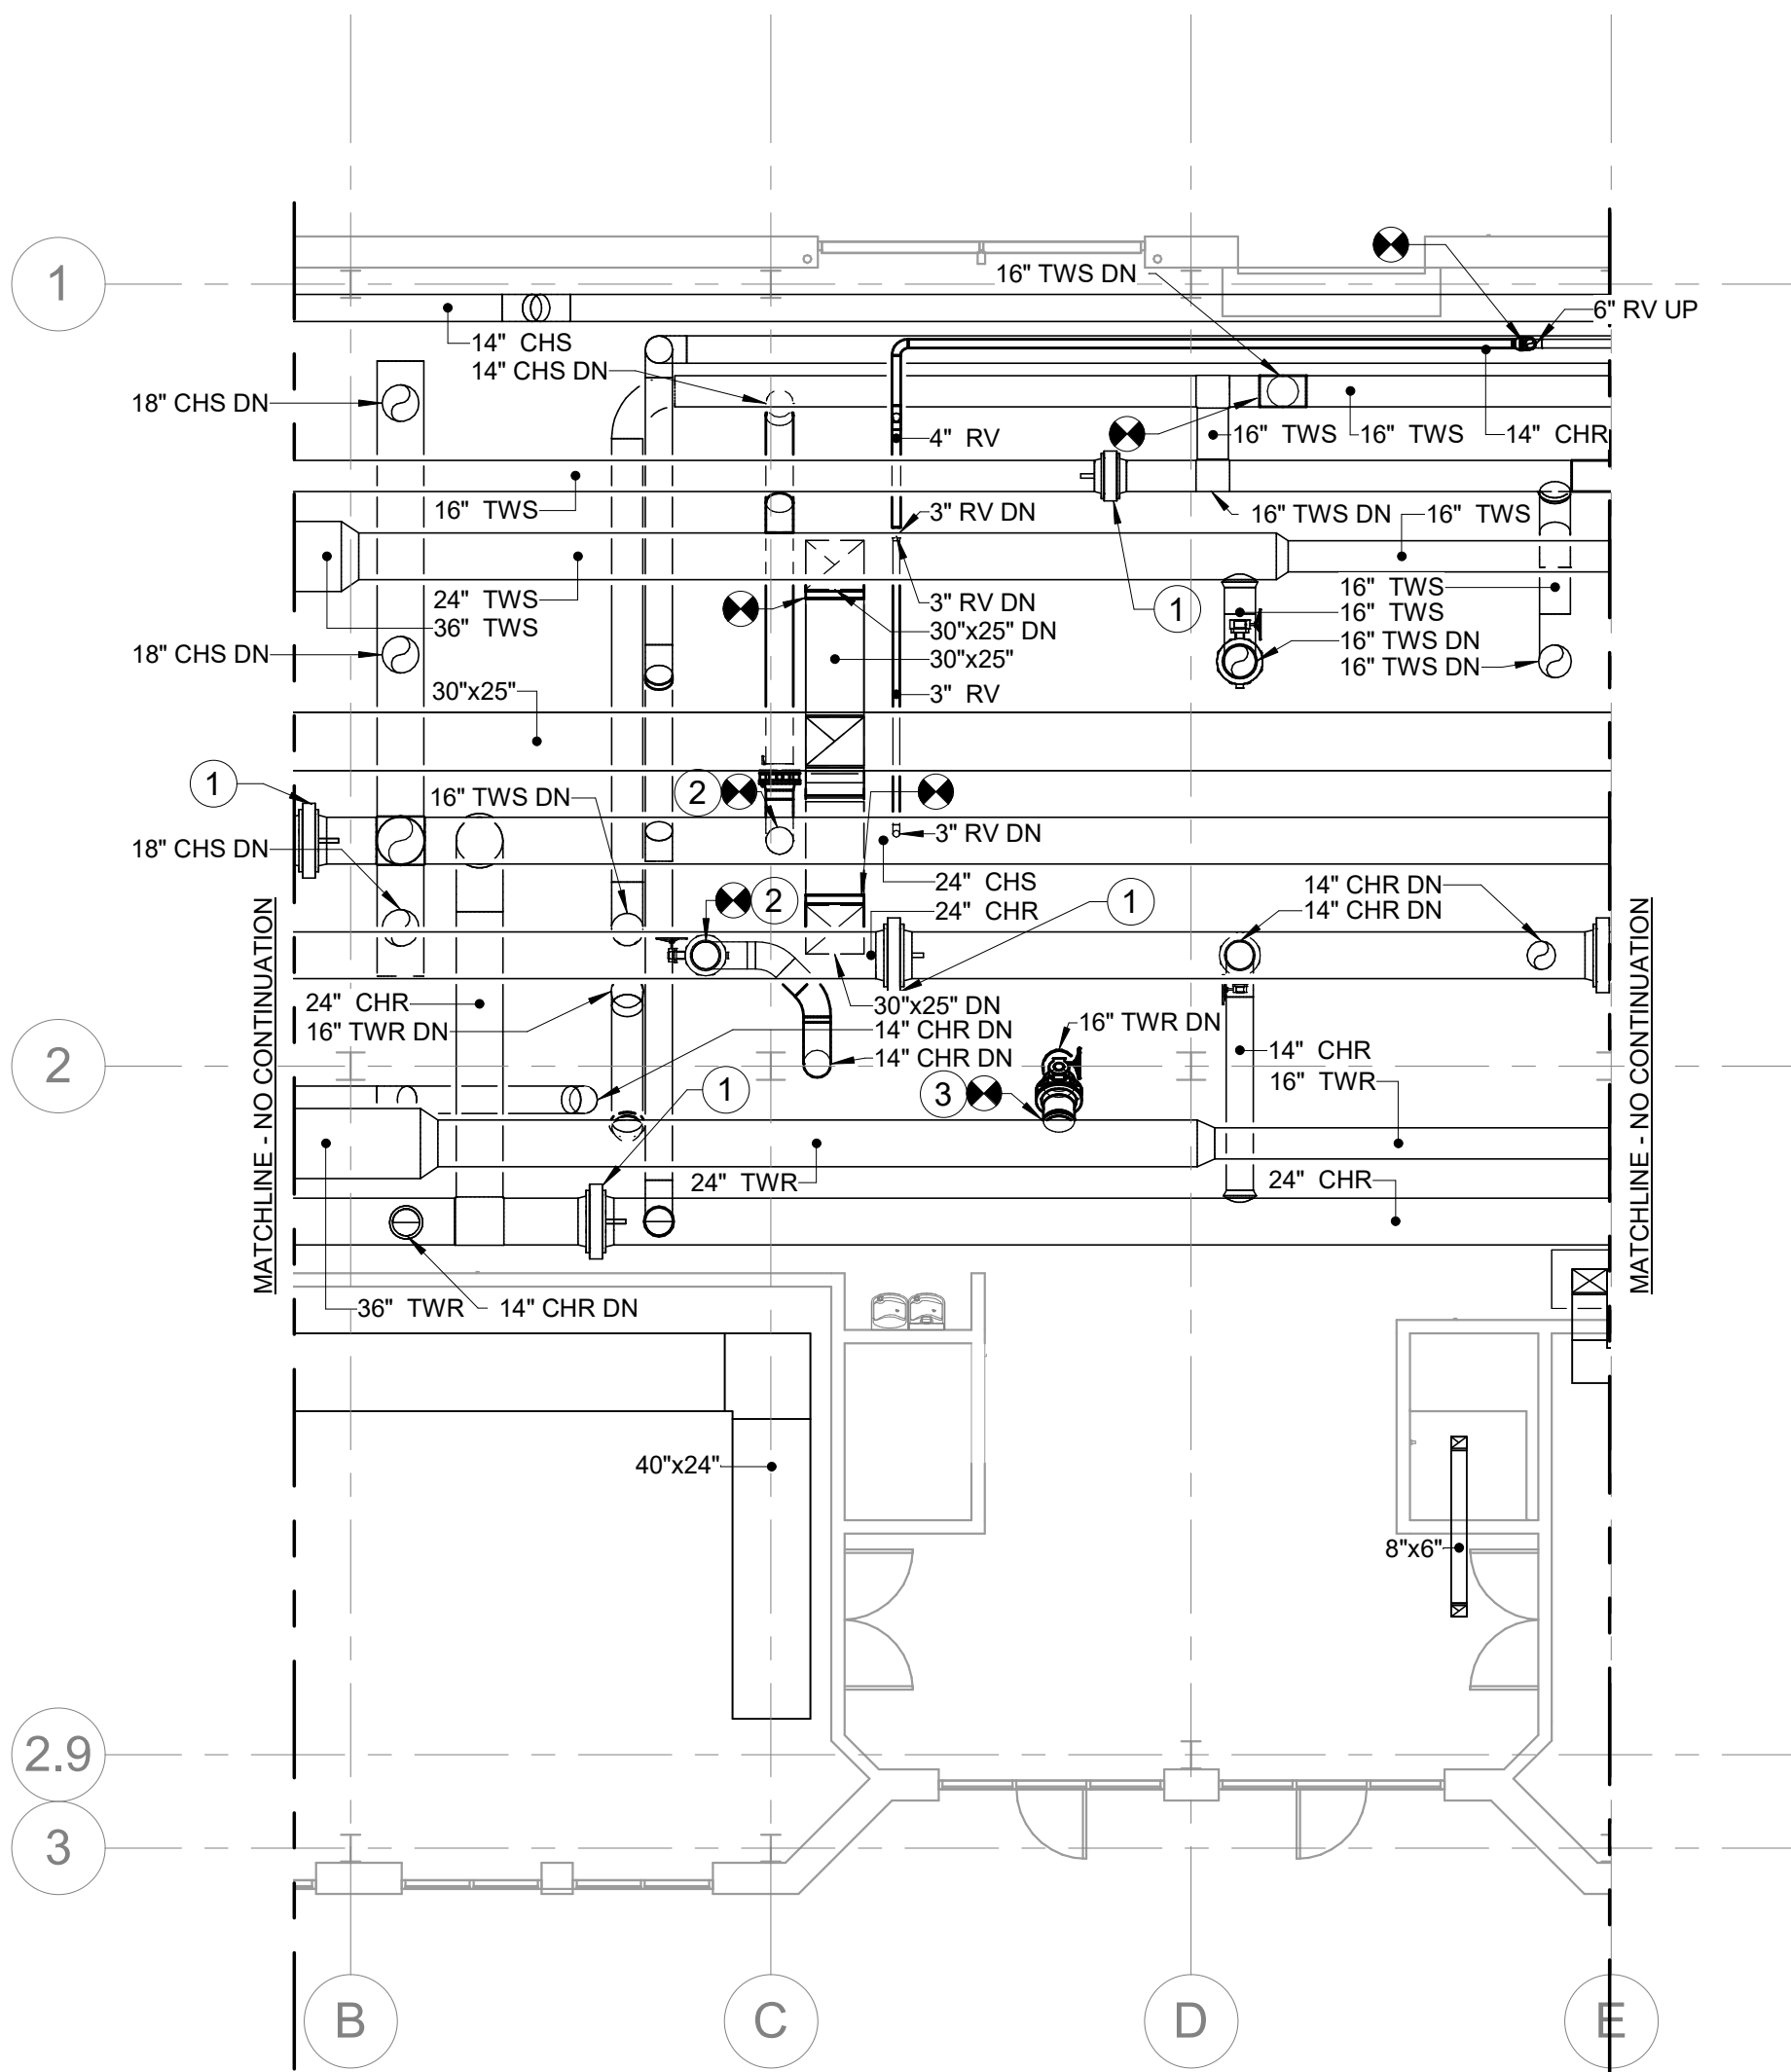


MECHANICAL - UPPER LEVEL - NEW WORK
SCALE: 1/8" = 1'-0"



 KEY PLAN



RMF ENGINEERING, INC.
194 SEVEN FARM DRIVE
SUITE G
CHARLESTON, SC 29492
P: 843-971-9639 F: 843-971-9641

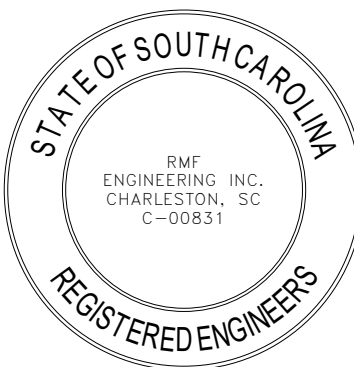

REV	DESCRIPTION	DATE
REVISIONS		

SUBMISSION TITLE:
Bid Documents

THIS DRAWING AND ALL COPIES THEREOF IS THE PROPERTY OF RMF ENGINEERING, INC. THIS DRAWING MAY NOT BE USED OR REPRODUCED WITHIN ANY COMPUTER ENVIRONMENT OR BY ANY PRINTING MEDIA WITHOUT THE WRITTEN CONSENT OF RMF ENGINEERING, INC.

SEAL:

DRAWN BY: KJA DATE: 06/12/2026
DESIGNED BY: KJA SCALE: 1/8" = 1'-0"
CHECKED BY: SOD RMF JOB NO.: 03250472.B0
PROJ. MGR.: DWZ CLIENT JOB #: H27-2821 50003714

 
PROJECT NAME:
**CHILLER AND
INFRASTRUCTURE
REPLACEMENT - NORTH
CH#2**

PROJECT ADDRESS:
**701 Park St, Columbia, SC
29208**

DRAWING TITLE:
MECHANICAL - NEW WORK

DRAWING NUMBER:

M-101




- 
- RMF ENGINEERING, INC.
194 SEVEN FARM DRIVE
SUITE G
CHARLESTON, SC 29492
P: 843-971-9639 F: 843-971-9641

M-301


M-301

Autodesk Docs/0325047280_USC North Energy Plant Chiller 2 Replacement/03250472 BO_MEP_22.rvt

6/12/2026 10:36:34 AM

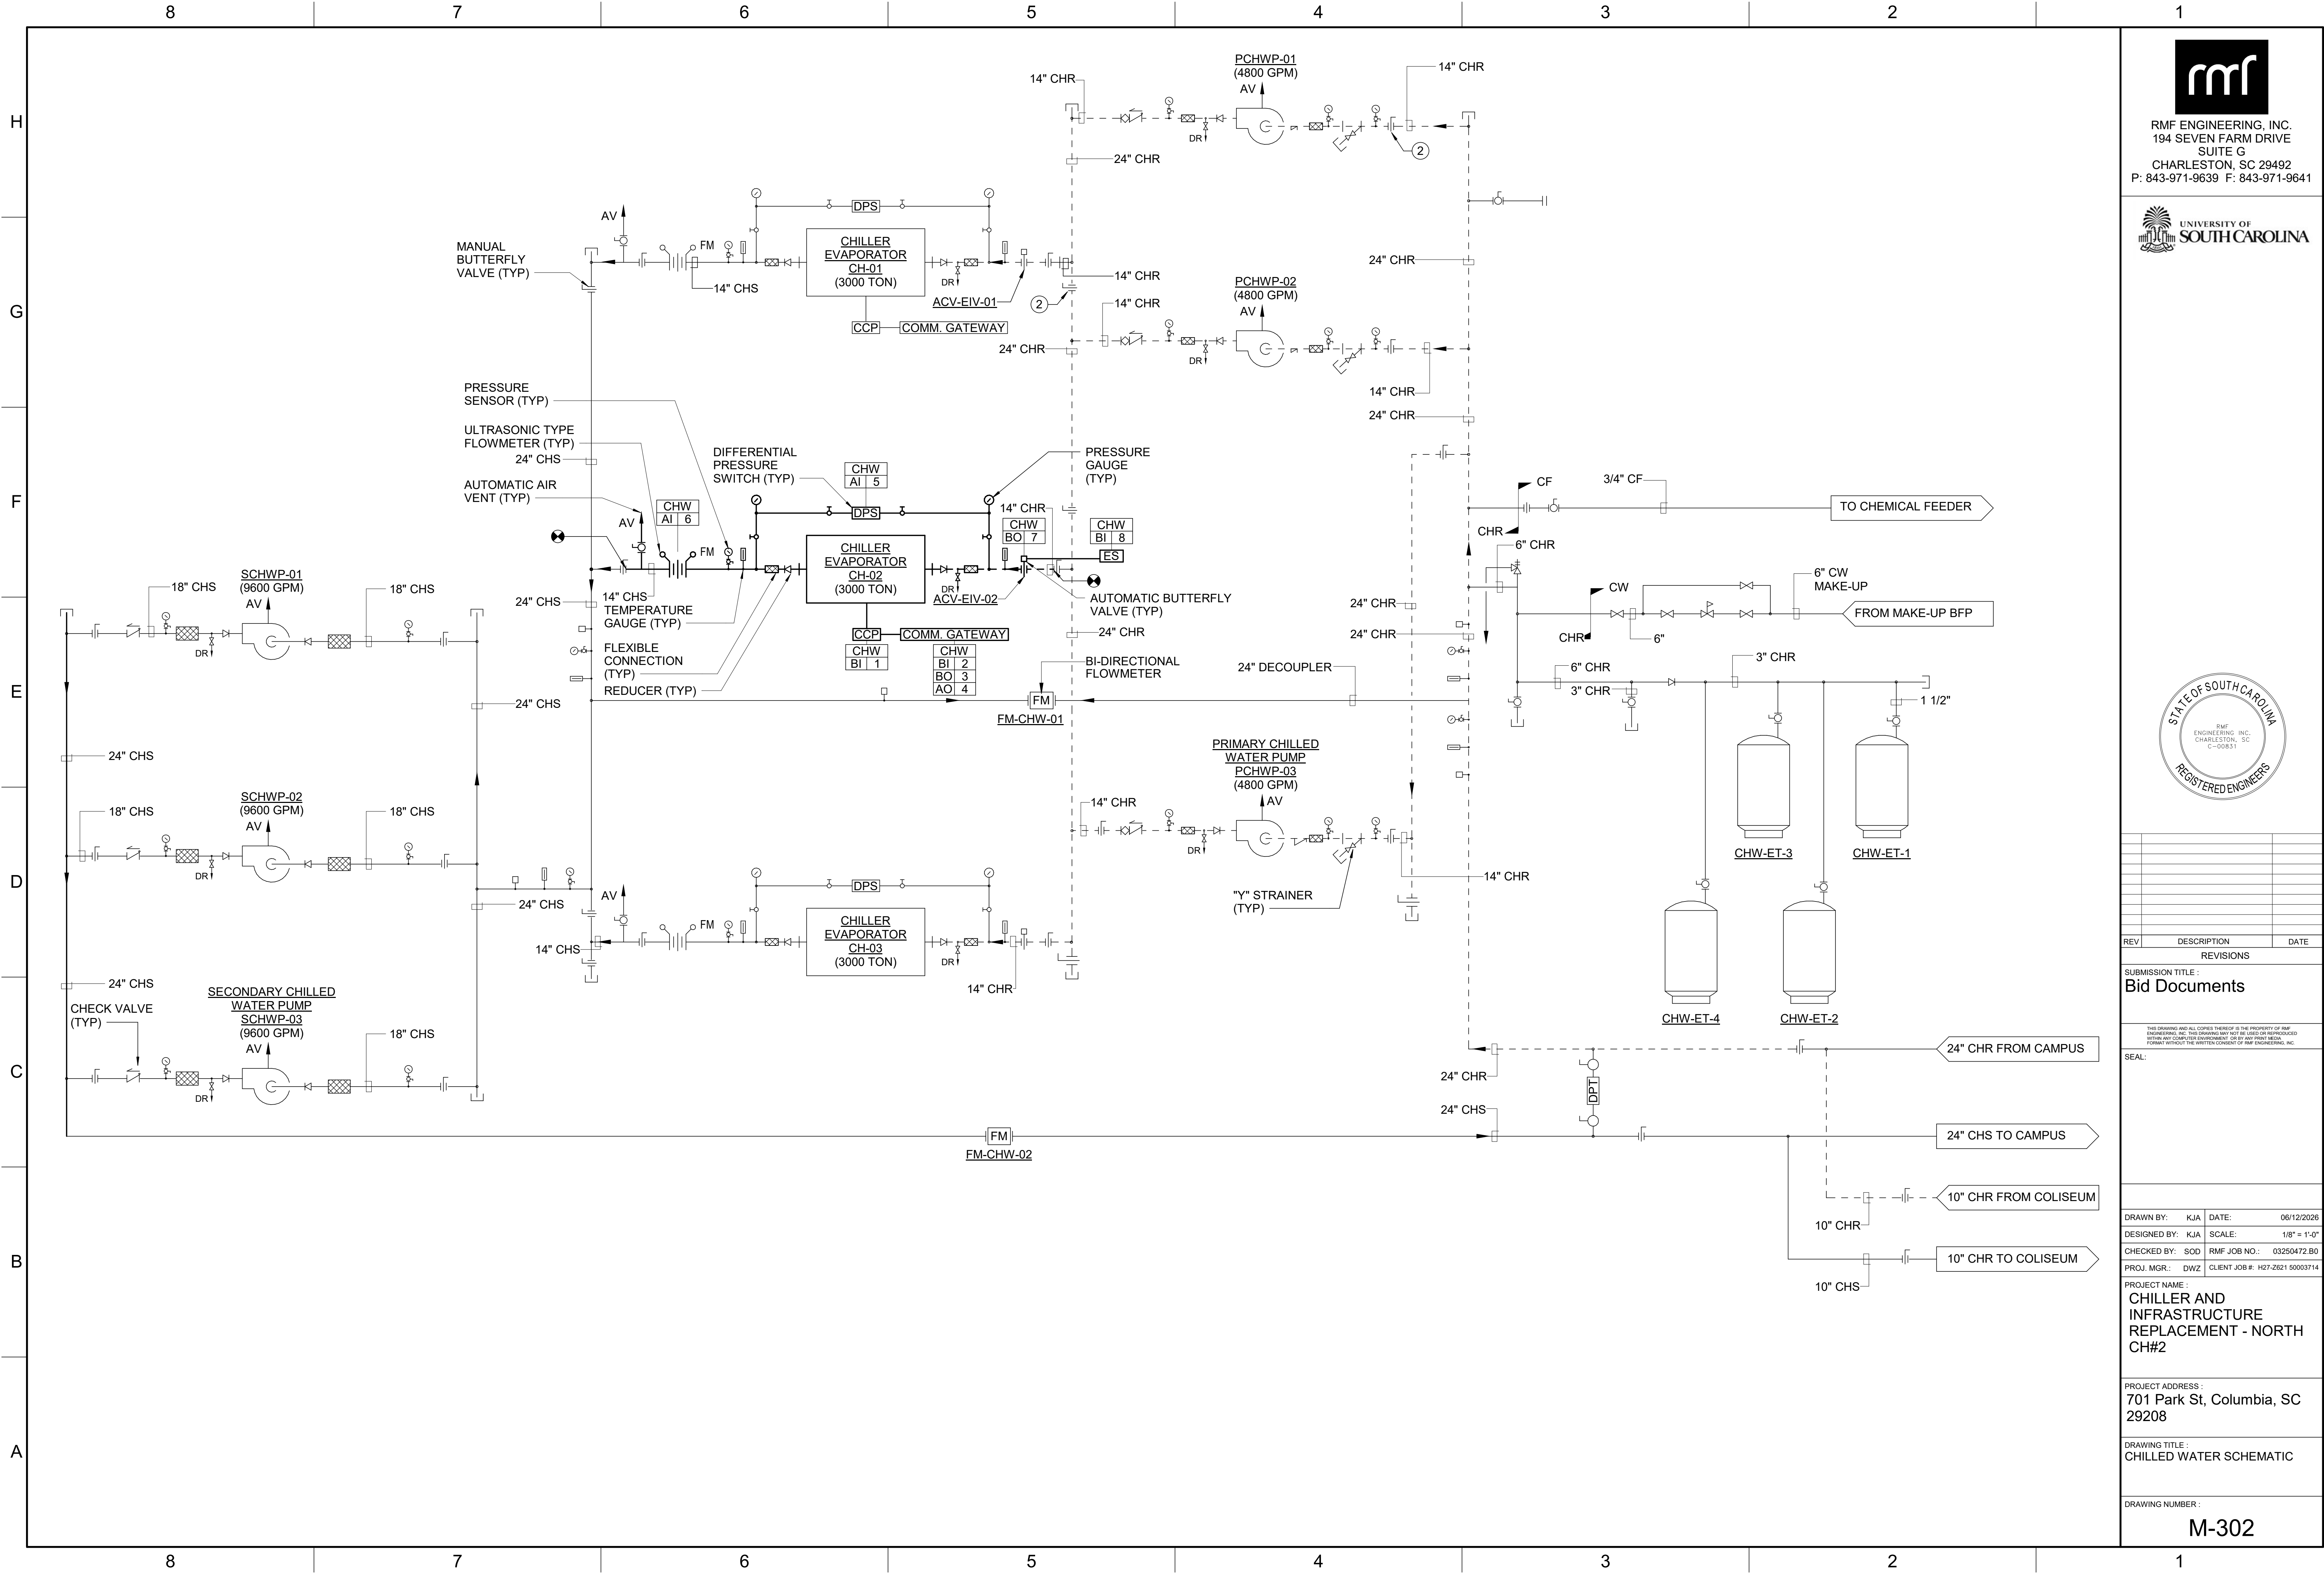

RMF ENGINEERING, INC.
194 SEVEN FARM DRIVE
SUITE G
CHARLESTON, SC 29492
P: 843-971-9639 F: 843-971-9641

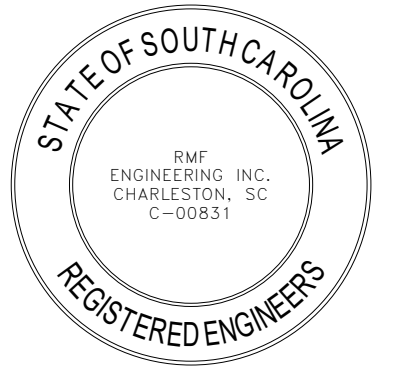

REV	DESCRIPTION	DATE
REVISIONS		

SUBMISSION TITLE:
Bid Documents

THIS DRAWING AND ALL COPIES THEREOF IS THE PROPERTY OF RMF ENGINEERING, INC. THIS DRAWING MAY NOT BE USED OR REPRODUCED WITHOUT ANY COMPUTER EQUIPMENT, OR BY ANY PHOTO MEANS, WITHOUT THE WRITTEN CONSENT OF RMF ENGINEERING, INC.

SEAL:

DRAWN BY: KJA DATE: 06/12/2026
DESIGNED BY: KJA SCALE: 1/8" = 1'-0"
CHECKED BY: SOD RMF JOB NO.: 03250472.B0
PROJ. MGR.: DWZ CLIENT JOB #: H27-2821 50003714

PROJECT NAME:
CHILLER AND INFRASTRUCTURE REPLACEMENT - NORTH CH#2

PROJECT ADDRESS:
701 Park St, Columbia, SC 29208

DRAWING TITLE:
CHILLED WATER SCHEMATIC

DRAWING NUMBER:

M-302

Autodesk Docs://0325047280-USC North Energy Plant Chiller 2 Replacement/03250472 BO_MEP_22.rvt

6/12/2026 10:36:34 AM

8

7

6

5

4

3

2

1

H

G

F

E

D

C

B

A

H

G

F

E

D


C

B

A




RMF ENGINEERING, INC.
194 SEVEN FARM DRIVE
SUITE G
CHARLESTON, SC 29492
P: 843-971-9639 F: 843-971-9641

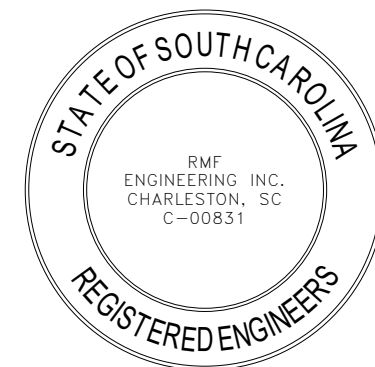

DRAWING NOTES

1. TAPS SHALL BE INSTALLED BEFORE ANY DEMOLITION OCCURS.
2. CLOSE MANUAL BUTTERFLY VALVE TO ISOLATE CHILLER FOR THE REMOVAL OF THE EXISTING CHILLER AND INSTALLATION OF THE NEW CHILLER.
3. PATCH THE MAIN AT POINT OF DISCONNECTION.

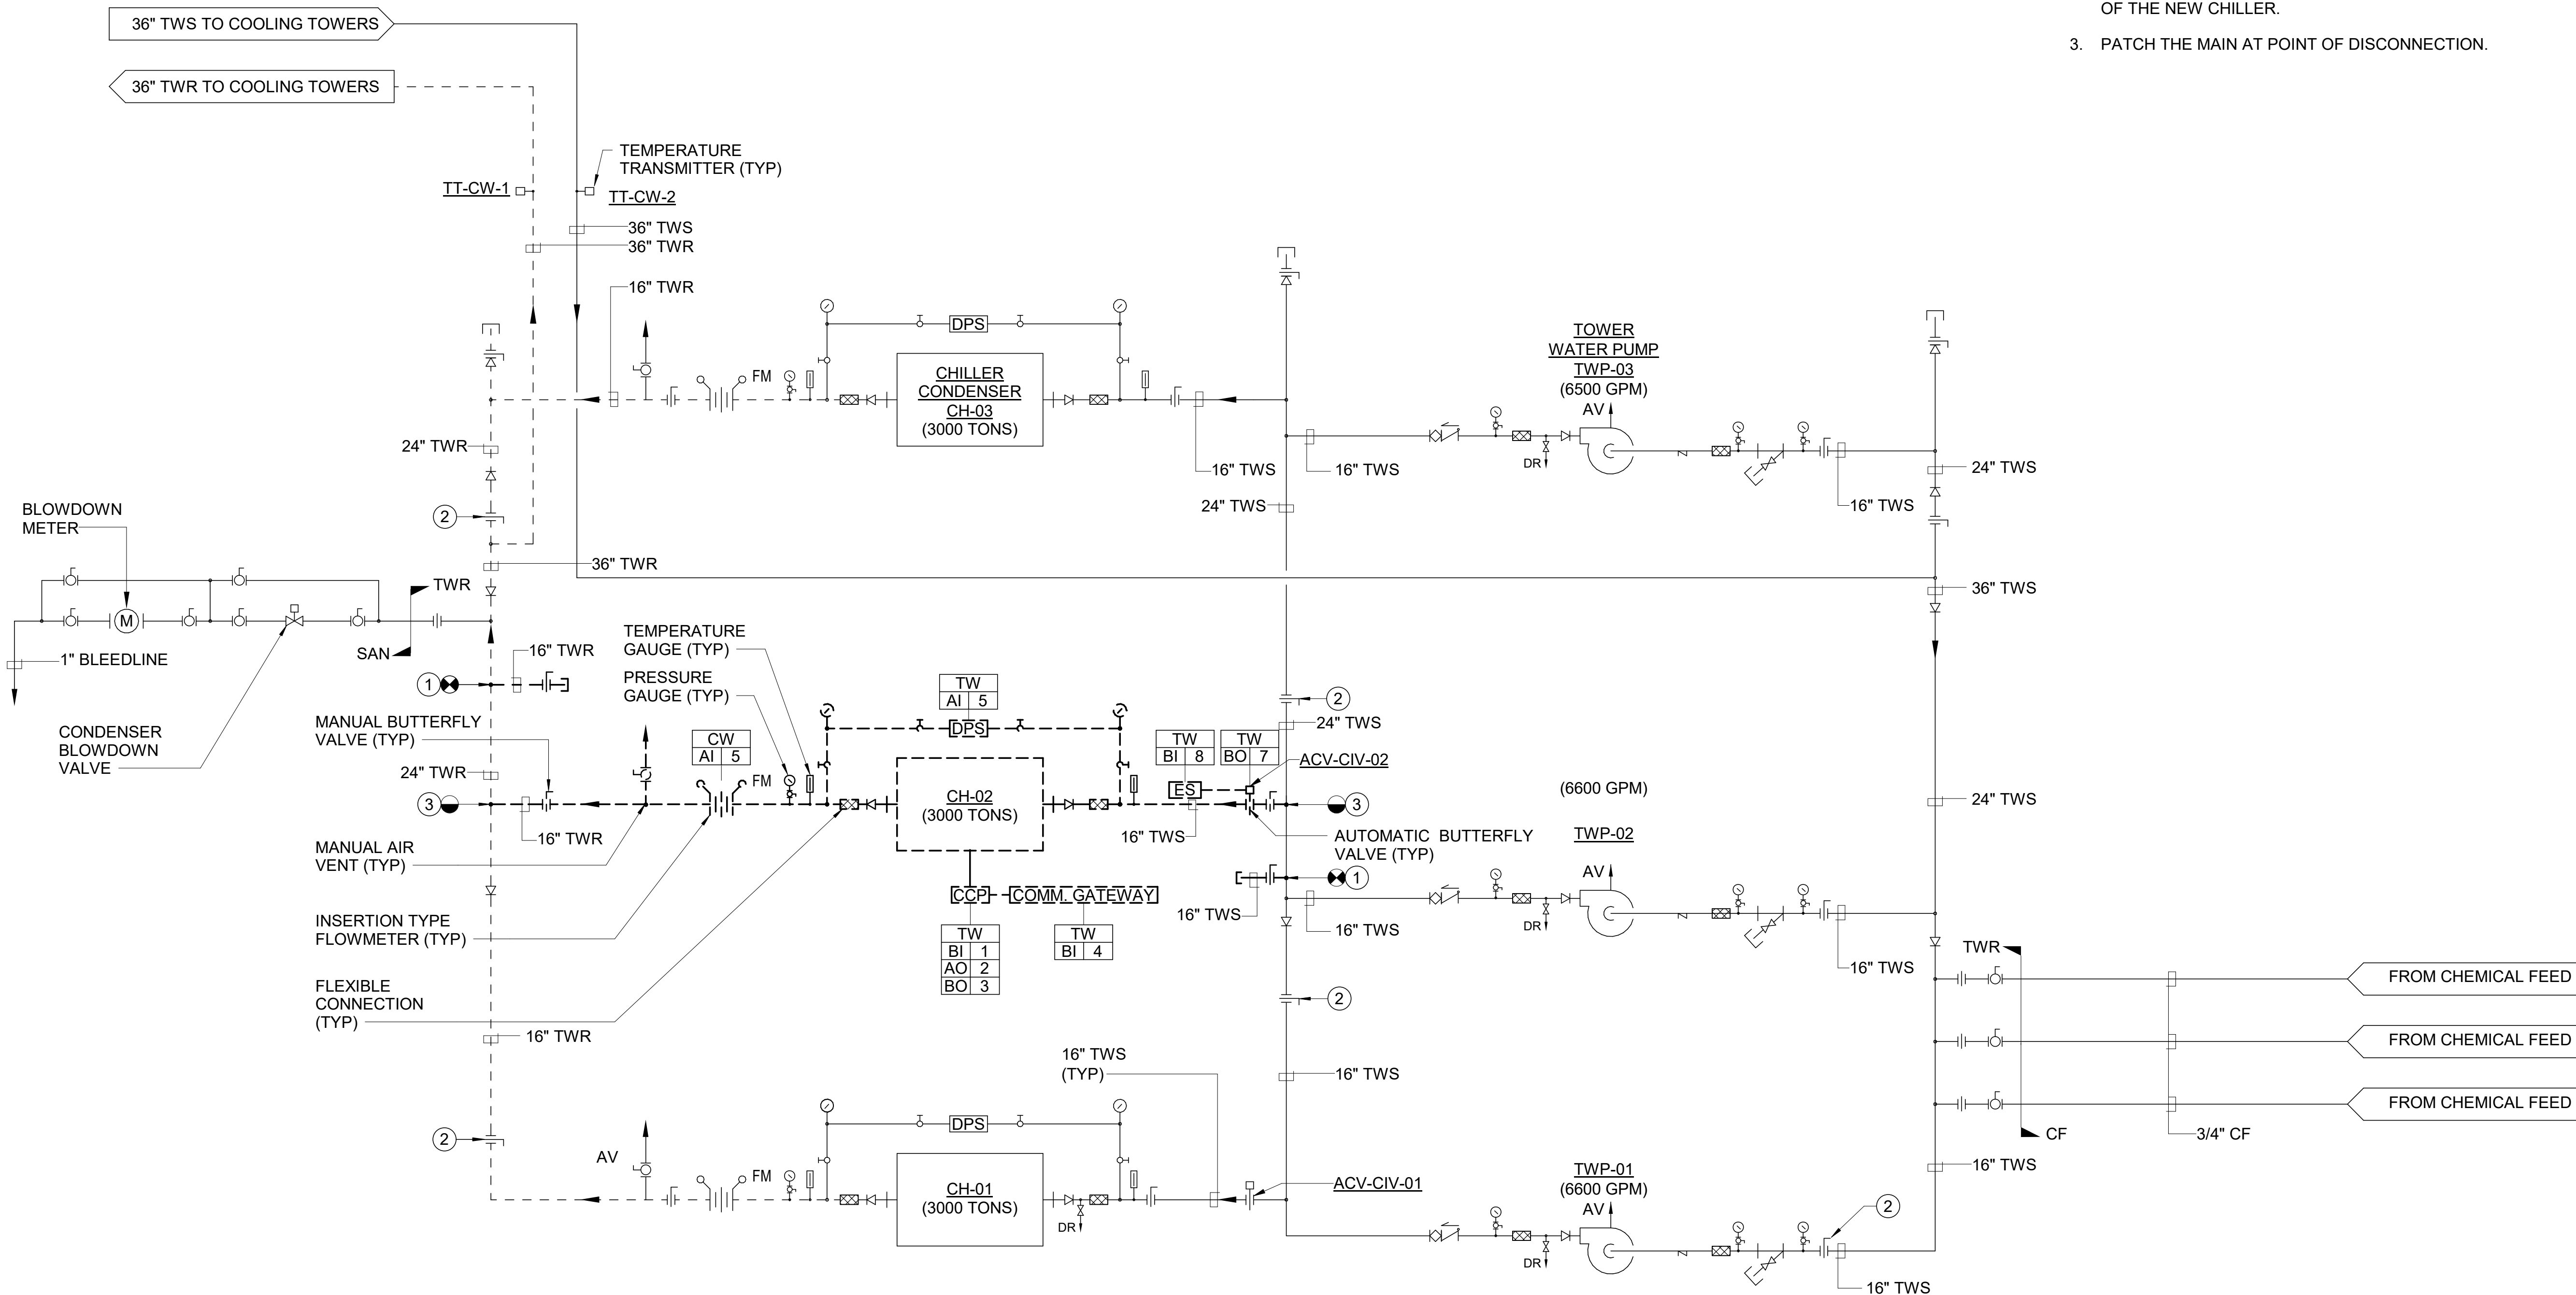

REV	DESCRIPTION	DATE
REVISIONS		

SUBMISSION TITLE :
Bid Documents

THIS DRAWING AND ALL COPIES THEREOF IS THE PROPERTY OF RMF ENGINEERING, INC. THIS DRAWING MAY NOT BE USED OR REPRODUCED WITHOUT ANY COMPUTER EQUIPMENT, OR BY ANY PHOTO MEANS, WITHOUT THE WRITTEN CONSENT OF RMF ENGINEERING, INC.

SEAL:

DRAWN BY: KJA DATE: 06/12/2026

DESIGNED BY: KJA SCALE: 1/8" = 1'-0"

CHECKED BY: SOD RMF JOB NO.: 03250472.B0

PROJ. MGR.: DWZ CLIENT JOB #: H27-2821 50003714

PROJECT NAME :
**CHILLER AND
INFRASTRUCTURE
REPLACEMENT - NORTH
CH#2**

PROJECT ADDRESS :
**701 Park St, Columbia, SC
29208**

DRAWING TITLE :
**TOWER WATER SCHEMATIC -
DEMOLITION**

DRAWING NUMBER :

M-303

8

7

6


5

4


3

2

1

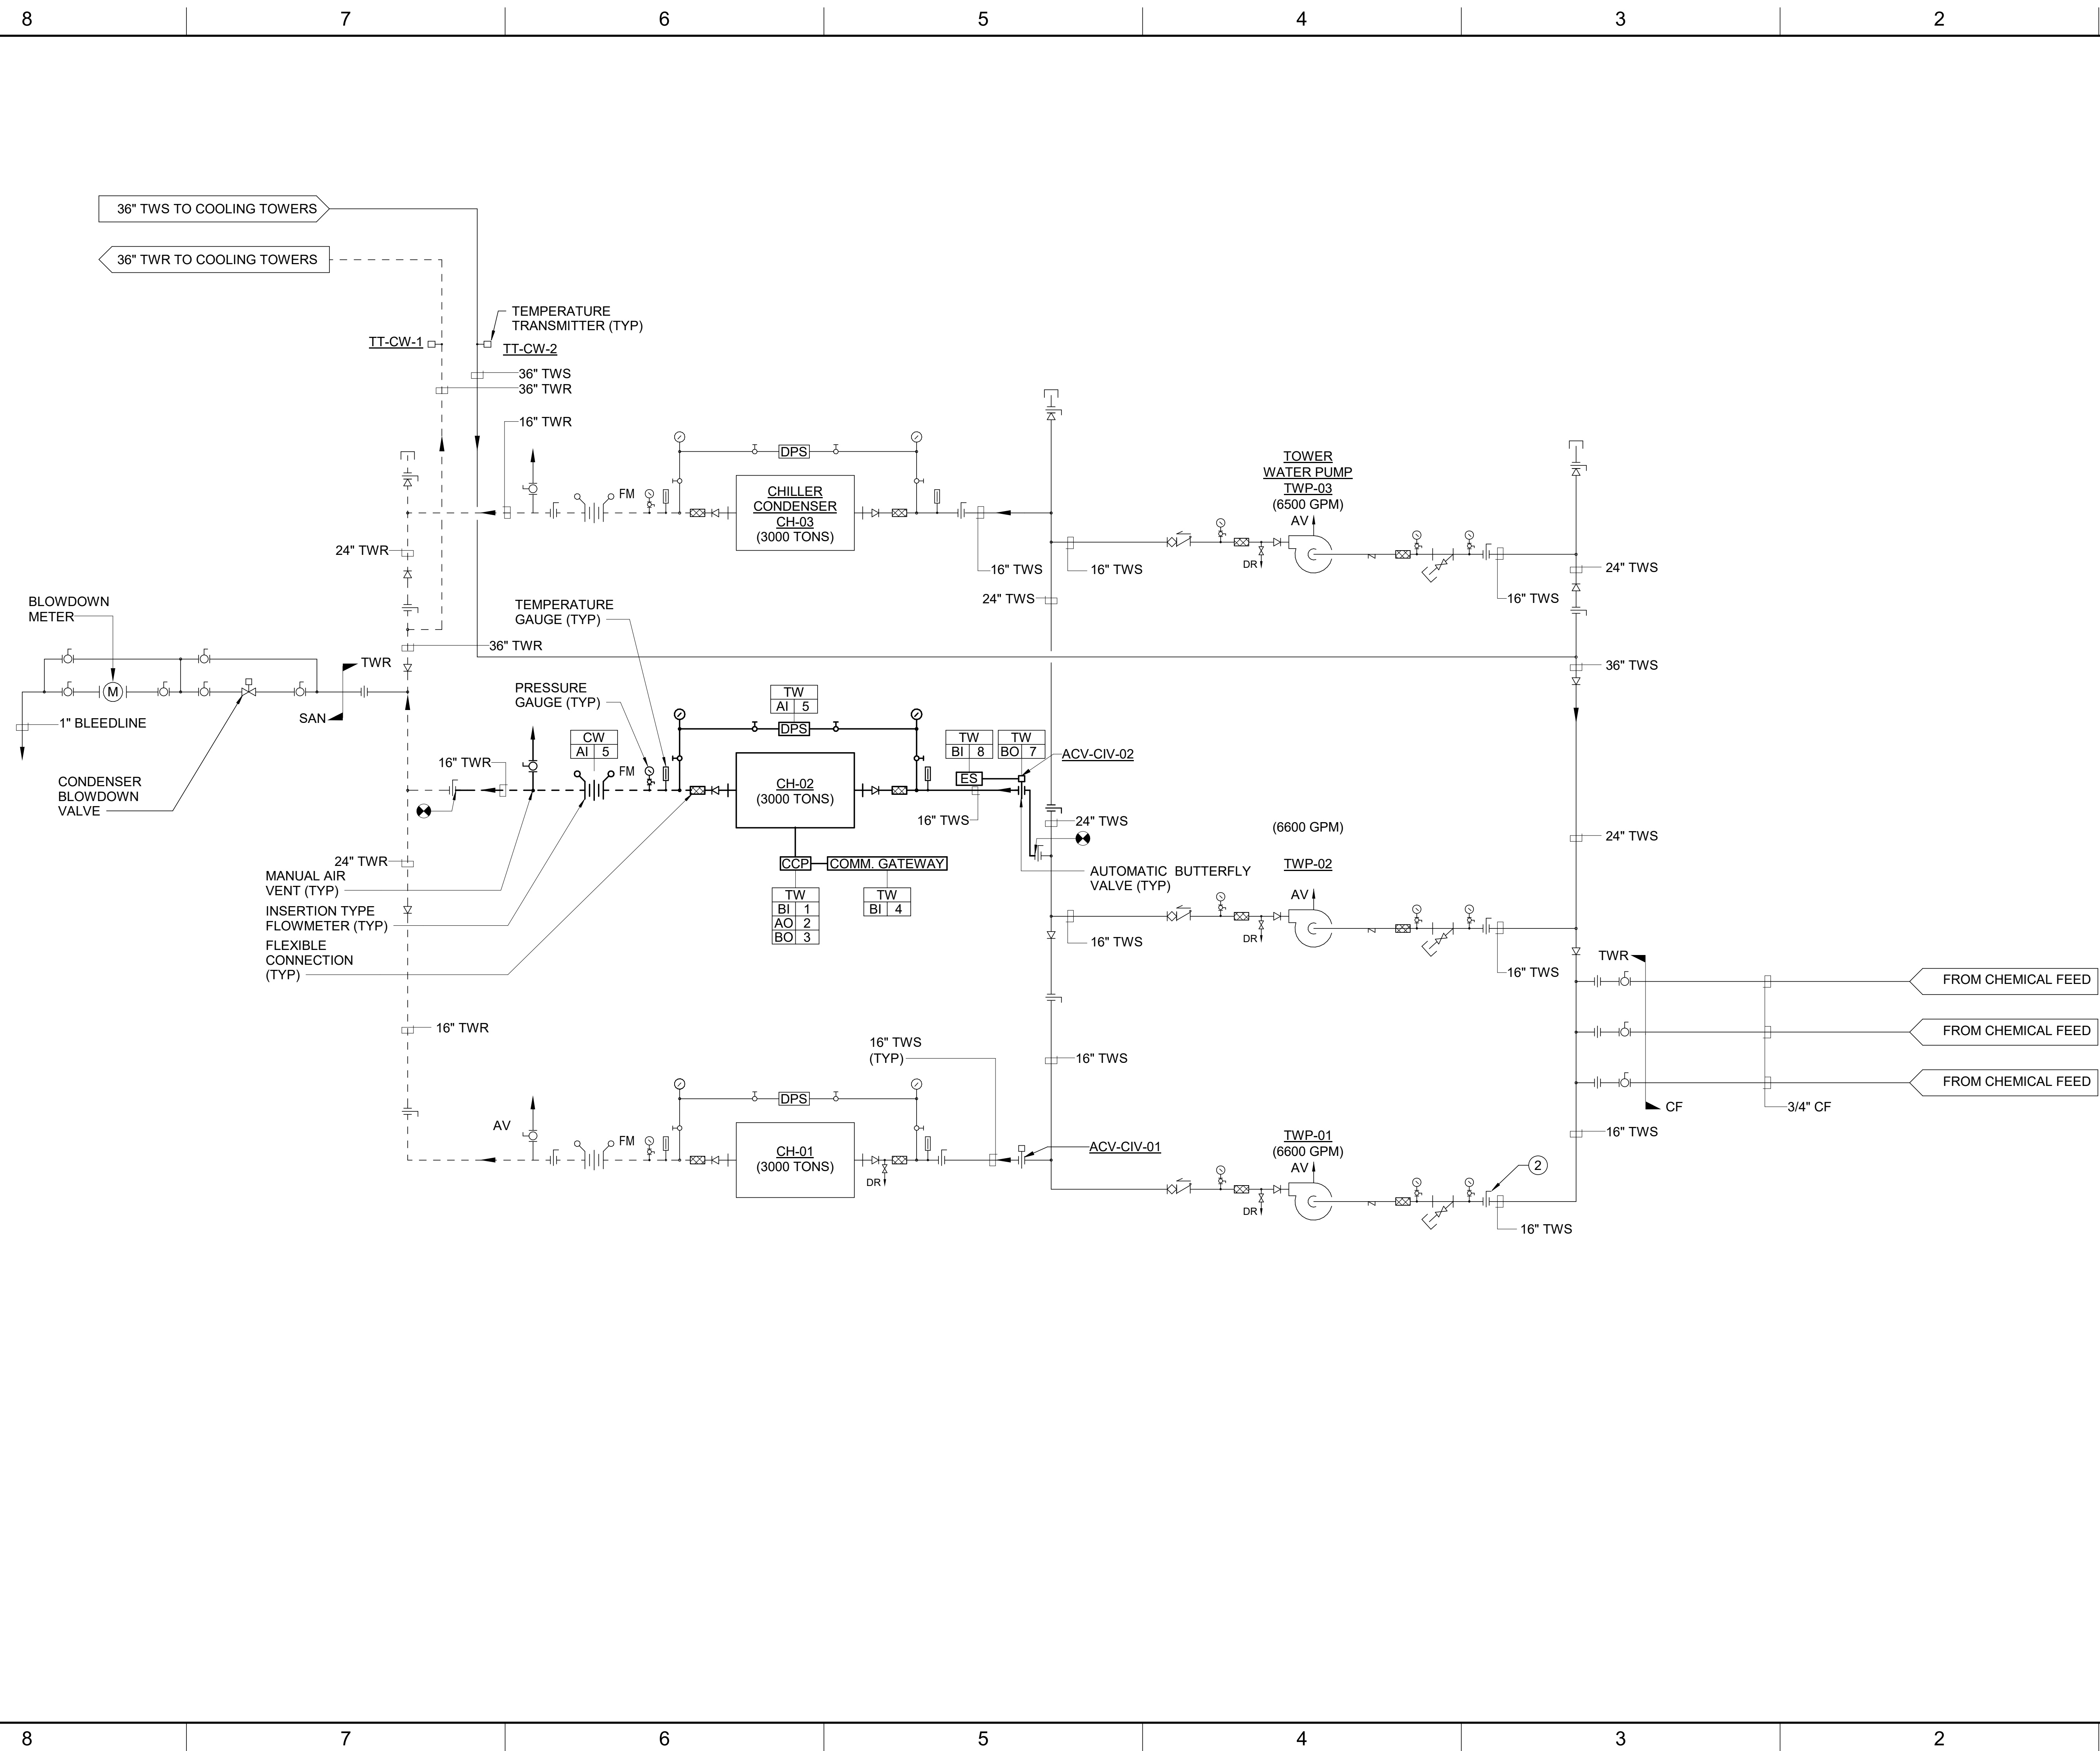

RMF ENGINEERING, INC.
194 SEVEN FARM DRIVE
SUITE G
CHARLESTON, SC 29492
P: 843-971-9639 F: 843-971-9641

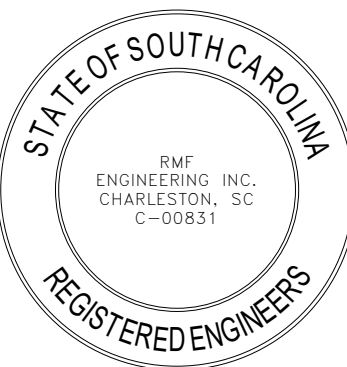

REV	DESCRIPTION	DATE
REVISIONS		

SUBMISSION TITLE :
Bid Documents

THIS DRAWING AND ALL COPIES THEREOF IS THE PROPERTY OF RMF ENGINEERING, INC. THIS DRAWING MAY NOT BE USED OR REPRODUCED WITHIN ANY COMPUTER ENVIRONMENT OR BY ANY PRINT MEDIA WITHOUT WRITING THE WRITTEN CONSENT OF RMF ENGINEERING, INC.

SEAL:

DRAWN BY: KJA	DATE: 06/12/2012
DESIGNED BY: KJA	SCALE: 1/8" = 1'-0"
CHECKED BY: SOD	RMF JOB NO.: 03250472.B
PROJ. MGR.: DWZ	CLIENT JOB #: H27-Z621 500037

PROJECT NAME :
CHILLER AND
INFRASTRUCTURE
REPLACEMENT - NORTH
CH#2

PROJECT ADDRESS :
701 Park St, Columbia, SC
29208

DRAWING TITLE :
TOWER WATER SCHEMATIC

DRAWING NUMBER :

M-304

[illegible]

6/10/2026 11:31:18 AM Autodesk Docs://0325047280-USC North Energy Plant Chiller 2 Replacement/03250472 BD_MEP_22.rvt

ELECTRICAL SYMBOLS

LIGHTING SYMBOLS

SYMBOL	DESCRIPTION	MH (UON)
§	SINGLE POLE TOGGLE SWITCH	48" TOD
§ _a	SWITCH: SUB-LETTER INDICATES FIXTURES CONTROLLED (a)	48" TOD
§ ₂	DOUBLE POLE TOGGLE SWITCH	48" TOD
§ ₃	THREE-WAY TOGGLE SWITCH (SPDT)	48" TOD
§ ₄	FOUR-WAY TOGGLE SWITCH (DPDT)	48" TOD
§ _K	KEY OPERATED SWITCH	48" TOD
§ _{3D a}	THREE WAY DIMMER SWITCH: SUBLETTER INDICATES FIXTURES CONTROLLED (a)	48" TOD
§ _M	MANUAL STARTER W/ OVERLOADS	48" TOD
§ _P	SWITCH W/ PILOT LIGHT	48" TOD
§ _D	DIMMER SWITCH	48" TOD
§ _{4D}	4 BUTTON DIMMER SWITCH	48" TOD
§ _{LV}	LOW VOLTAGE CONTROL SWITCH	48" TOD
§ _T	MANUAL TIME SWITCH	48" TOD
§ _C	MOMENTARY CONTACT SWITCH	48" TOD
§ _{WP}	SWITCH WITH WEATHERPROOF ENCLOSURE	48" TOD
Ⓢ Ⓞ	OCCUPANCY SENSOR (CEILING & WALL MOUNTED)	
Ⓥ	VACANCY SENSOR	
Ⓣ	TIME CLOCK	
Ⓡ	RELAY	
Ⓛ	LIGHTING CONTACTOR	
Ⓟ	PHOTOCELL OR PUSHPLATE SWITCH	
UL924	EMERGENCY SHUNT RELAY, UL 924 LISTED (CEILING MOUNTED)	
○ ○	LIGHTING FIXTURE: RECESSED, SURFACE, OR PENDANT MOUNTED - TYPE AS SPECIFIED	
○ ○	LIGHTING FIXTURE: 2 BALLAST	
⎓	LIGHTING FIXTURE: INDUSTRIAL	
□	LIGHTING FIXTURE: WALL MOUNTED - TYPE AS SPECIFIED	
○	LIGHTING FIXTURE: RECESSED, SURFACE, OR PENDANT MOUNTED	
○	LIGHTING FIXTURE: WALL MOUNTED - TYPE AS SPECIFIED	
●	WALL WASHER	
<○	ADJUSTABLE WALL WASHER	
● ●	LIGHTING FIXTURE ON EMERGENCY OR NIGHT LIGHT CIRCUIT (NL)	
⎓	EMERGENCY BATTERY PACK: W/ NUMBER OF HEADS INDICATED	
⎓	EMERGENCY BATTERY PACK: W/ REMOTE HEADS	
⌚	REMOTE EMERGENCY HEAD	
⎓	EMERGENCY BATTERY PACK: SEMI RECESSED, CEILING MOUNT	
⊗	EXIT SIGN: CEILING OR PENDANT MOUNTED (SHADED PORTION INDICATES FACE)	
⎓ ⊗	EXIT SIGN: WALL MOUNTED - END, BACK	
⎓ ⊗	EXIT SIGN: W/ DIRECTIONAL ARROWS	
□ □	POLE MOUNTED LIGHTING FIXTURE: SINGLE HEAD, DOUBLE HEAD	
⌘	POLE MOUNTED LIGHTING FIXTURE: SINGLE, POLE TOP	
⎓	LIGHTING POLE (SPORTS)	

SPECIAL SYSTEMS SYMBOLS


SYMBOL	DESCRIPTION	MH (UON)
⎓	FIRE ALARM HORN TYPE SPEAKER	NOTE 5
⎓	FIRE ALARM FLASHING STROBE LIGHT - WALL MOUNTED	NOTE 5
⎓	FIRE ALARM HORN	NOTE 5
⎓	COMBINATION FIRE ALARM HORN AND FLASHING STROBE LIGHT	NOTE 5
Ⓢ Ⓟ	S - CEILING SPEAKER, F - FIRE ALARM SPEAKER	
Ⓢ	FIRE ALARM SPEAKER W/ STROBE	
⎓	HORN TYPE SPEAKER	
Ⓡ	MAGNETIC DOOR HOLDER	
DACT	DIGITAL ALARM COMMUNICATOR TRANSMITTER	
FAAP	FIRE ALARM ANNUNCIATOR PANEL	
FACP	FIRE ALARM CONTROL PANEL	
RAM	RESCUE ASSISTANCE MASTER CONTROL PANEL	48" TOD
RAR	RESCUE ASSISTANCE REMOTE STATION	48" TOD
TP	FIRE ALARM TRANSPONDER	
DSIES	DOOR SOLENOID, ELECTRIC STRIKE - LOCKING DEVICE CONNECTION POINT	
⎓	FIRE ALARM PULL STATION	48" TOD
⎓ ⎓	HEAT DETECTOR: E = ELEVATOR CONTROLS	
⎓ ⎓	SMOKE DETECTOR (PHOTOELECTRIC); AB = AUDIBLE BASE, E = ELEVATOR CONTROLS	
⎓	SMOKE DETECTOR (IONIZATION)	
⎓	FIRE ALARM DUCT DETECTOR WITH RELAY	
⎓	CARBON MONOXIDE DETECTOR	
ARCO	FIRE ALARM SYSTEM ADDRESSABLE RELAY - CONTROL	
ARM	FIRE ALARM SYSTEM ADDRESSABLE RELAY - MONITOR	
RAL	FIRE ALARM SYSTEM REMOTE ALARM LIGHT	
FS	FLOW SWITCH CONNECTION	
TS	TAMPER SWITCH CONNECTION	
⎓ ⎓	FIRE ALARM LINEAR BEAM SMOKE DETECTOR: TRANSMITTER (LBT) AND RECEIVER (LBR)	

SPECIAL SYSTEMS SYMBOLS

SYMBOL	DESCRIPTION	MH (UON)
▼ ^F	FIRE FIGHTER'S TELEPHONE JACK	48" TOD
Ⓜ	MONITOR SYSTEM JUNCTION BOX	36" CTR
Ⓐ	AMPLIFIER	
Ⓚ	KEYPAD	48" TOD
CR	CARD READER	48" TOD
DA	DOOR ALARM CONTACT	
⎓	ROUGH-IN JUNCTION BOX FOR CCTV CAMERA	
Ⓟ	PUSH BUTTON PLATE	
▼	TELEVISION ANTENNA OUTLET	18" CTR
Ⓢ	CABLE TV OUTLET	
⎓ ⎓	TELEVISION SYSTEM SPLITTER - 2 WAY, 4 WAY	
CD	A/V CREDENZA LOCATION	
IP	A/V INPUT PLATE	
Ⓡ	A/V IN-WALL RACK	
MT	A/V MONITOR TV	
SC	A/V SCREEN CONTROL	
SP	A/V SCHEDULING PANEL	
ST	A/V SIGNAGE TV	
TP	A/V TOUCH PANEL	
▼	DATA/TELEPHONE OUTLET, CEILING MOUNTED	
▼	TELEPHONE OUTLET	18" CTR
▼	DATA OUTLET	18" CTR
▼ ^W	TELEPHONE OUTLET, WALL MOUNTED	54" CTR
▼ ^E	TELEPHONE OUTLET, EMERGENCY	54" TOD
▼	DATA/TELEPHONE OUTLET: UNSHADED AREA = DATA, SHADED AREA = VOICE NUMERALS INDICATE QUANTITY OF WIRED JACKS	18" CTR
⎓	TELEPHONE OUTLET, FLOOR MOUNTED	
⎓	DATA OUTLET, FLOOR MOUNTED	
⎓	DATA/TELEPHONE OUTLET, FLOOR MOUNTED: UNSHADED AREA = DATA, SHADED AREA = VOICE NUMERALS INDICATE QUANTITY OF WIRED JACKS	
⎓ ⎓	COMBINATION POWER & TELEPHONE OUTLET, FLOOR MOUNTED	
⎓ ⎓	COMBINATION POWER & DATA OUTLET, FLOOR MOUNTED	
⎓ ⎓	COMBINATION POWER & DATA/TELEPHONE OUTLET, FLOOR MOUNTED	
WAP	WIRELESS ACCESS POINT	



RMF ENGINEERING, INC.
194 SEVEN FARM DRIVE
SUITE G
CHARLESTON, SC 29492
P: 843-971-9639 F: 843-971-9641

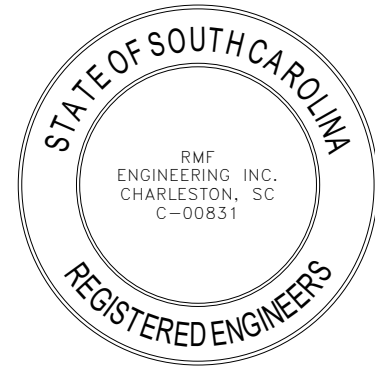

REV	DESCRIPTION	DATE
-----	-------------	------

REVISIONS

SUBMISSION TITLE :
Bid Documents

THIS DRAWING AND ALL COPIES THEREOF IS THE PROPERTY OF RMF ENGINEERING, INC. THIS DRAWING MAY NOT BE USED OR REPRODUCED WITHIN ANY COMPUTER ENVIRONMENT OR BY ANY PRINT MEDIA FORMAT WITHOUT THE WRITTEN CONSENT OF RMF ENGINEERING, INC.

SEAL:

DRAWN BY:	KJA	DATE:	06/12/2026
DESIGNED BY:	KJA	SCALE:	1/8" = 1'-0"
CHECKED BY:	SOD	RMF JOB NO.:	03250472.B0
PROJ. MGR.:	DWZ	CLIENT JOB #:	H27-2821 50003714

PROJECT NAME :
CHILLER AND INFRASTRUCTURE REPLACEMENT - NORTH CH#2

PROJECT ADDRESS :
701 Park St, Columbia, SC 29208

DRAWING TITLE :
ELECTRICAL NOTES, SYMBOLS AND ABBREVIATIONS

DRAWING NUMBER :


E-001

A	B	C	D	E	F	G	H
---	---	---	---	---	---	---	---

Autodesk Docs/0325047280-USC North Energy Plant Chiller 2 Replacement/03250472 BD MEP 22.rvt

6/10/2026 11:31:24 AM

H
G
F
E
D
C
B
A

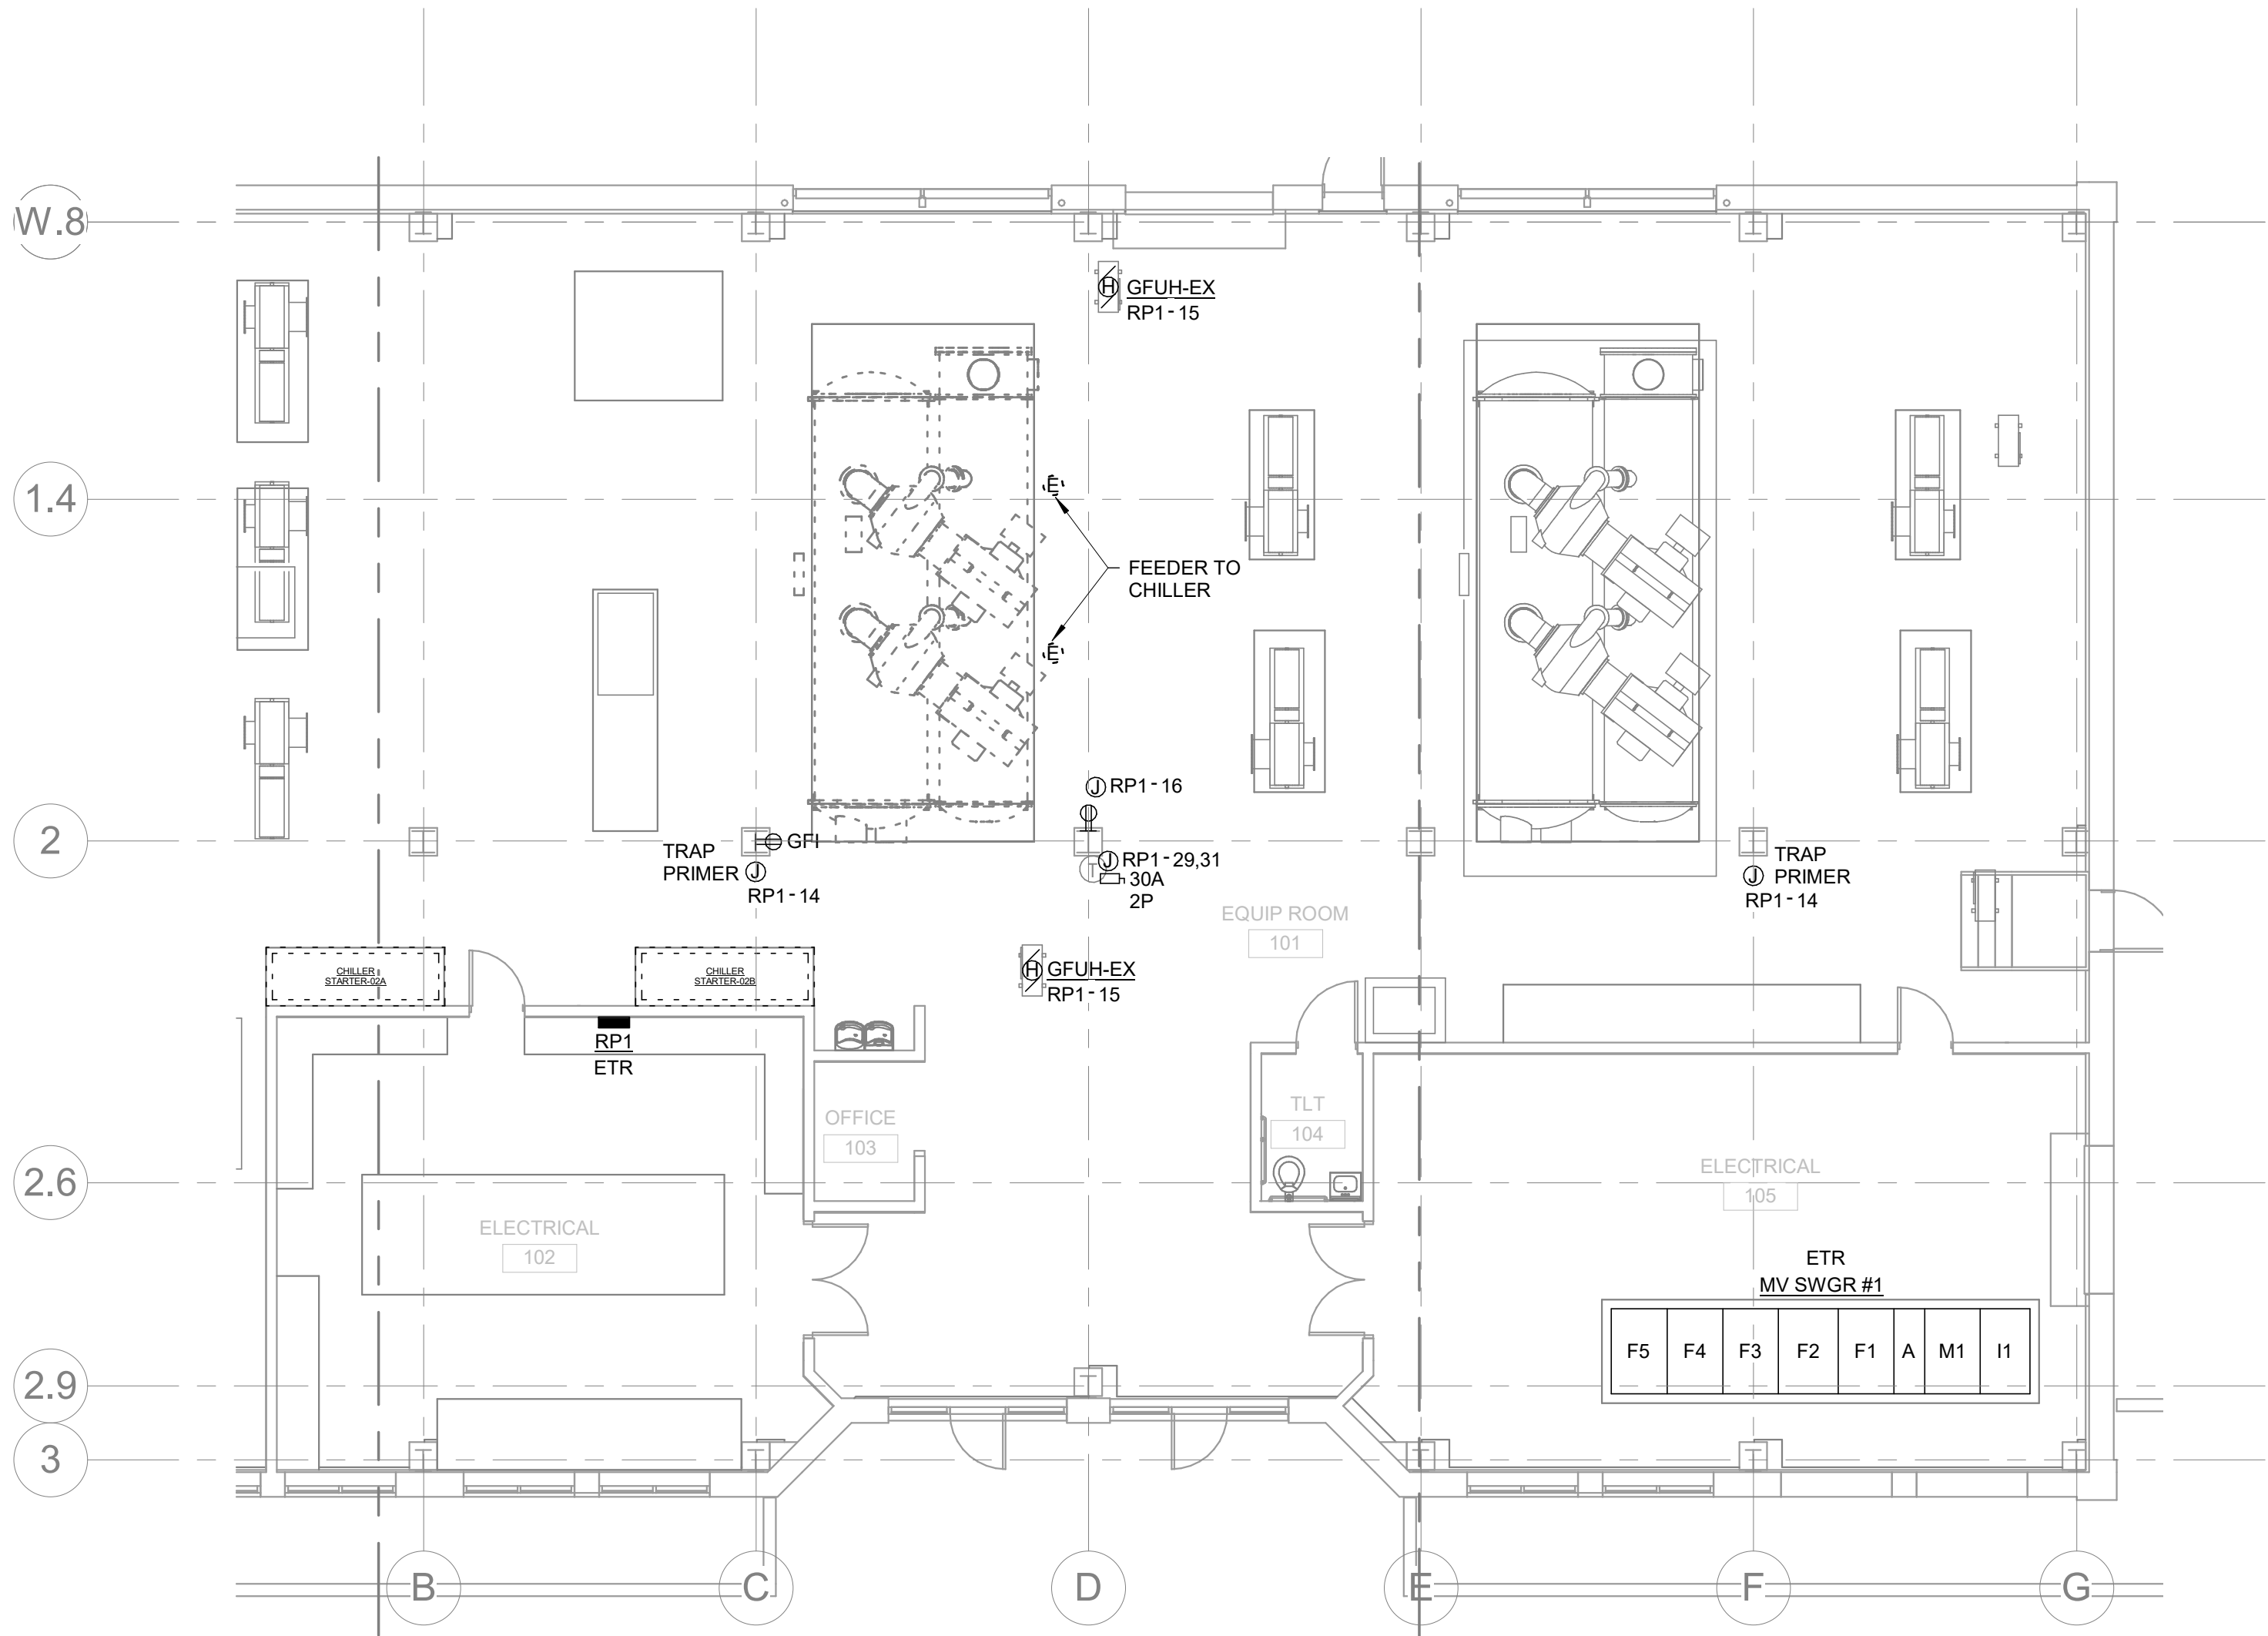


ELECTRICAL - DEMOLITION
SCALE: 1/8" = 1'-0"

DEMOLITION GENERAL NOTES

1. ITEMS INDICATED WITH HEAVY HATCHED LINES ARE TO BE REMOVED IN THEIR ENTIRETY. ITEMS THAT ARE EXISTING TO REMAIN ARE INDICATED WITH LIGHT CONTINUOUS LINES.
2. EXISTING CONDITIONS SUCH AS LIGHTING, RECEPTACLES, ETC. WERE OBTAINED FROM AVAILABLE RECORD DRAWINGS AND FIELD SURVEYS AND ARE NOT WARRANTED TO BE COMPLETE OR CORRECT. CONTRACTOR SHALL VERIFY EXACT LOCATION OF ALL ELECTRICAL ITEMS IN THE FIELD PRIOR TO THE START OF ANY WORK.
3. SHOULD THE CONTRACTOR ENCOUNTER ANY MAJOR ELECTRICAL ITEMS, I.E. PANELS, FEEDERS, JUNCTION BOXES ETC. WHICH ARE NOT ADDRESSED ON THE DRAWINGS, HE SHALL BRING THEM TO THE ATTENTION OF THE ENGINEER. THE ENGINEER WILL REVIEW THE ITEM IN QUESTION AND GIVE THE NECESSARY DIRECTION.
4. THE OWNER SHALL BE GIVEN A FIRST RIGHT OF REFUSAL FOR ALL ELECTRICAL EQUIPMENT WHICH IS TO BE REMOVED. ALL ELECTRICAL EQUIPMENT WHICH IS DESIRED BY THE OWNER SHALL BE STORED ON THE SITE WHERE DIRECTED BY THE OWNER. THE CONTRACTOR SHALL PROMPTLY DISPOSE OF ALL ELECTRICAL ITEMS WHICH ARE REMOVED AND THE OWNER DOES NOT WANT TO KEEP.
5. ALL BRANCH CIRCUIT AND TELEPHONE WIRING WHICH MUST BE IN SERVICE AND WHICH IS DISCONNECTED AS A RESULT OF THE DEMOLITION WORK SHALL BE PROPERLY RECONNECTED.
6. REMOVE ALL EMPTY RACEWAYS AND BOXES THAT HAVE BEEN ABANDONED.
7. RESUPPORT RACEWAYS AND BOXES THAT ARE INSUFFICIENTLY SUPPORTED WHICH ARE TO BE REUSED FOR NEW INSTALLATION.



RMF ENGINEERING, INC.
194 SEVEN FARM DRIVE
SUITE G
CHARLESTON, SC 29492
P: 843-971-9639 F: 843-971-9641

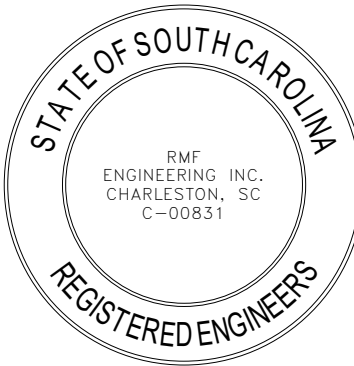

REV	DESCRIPTION	DATE

SUBMISSION TITLE :
Bid Documents

THIS DRAWING AND ALL COPIES THEREOF IS THE PROPERTY OF RMF ENGINEERING, INC. THIS DRAWING MAY NOT BE USED OR REPRODUCED WITHOUT ANY COMPUTER EQUIPMENT OR BY ANY PRINT MEDIA FORMAT WITHOUT THE WRITTEN CONSENT OF RMF ENGINEERING, INC.

SEAL:

 
DRAWN BY: KJA DATE: 06/12/2026
DESIGNED BY: KJA SCALE: 1/8" = 1'-0"
CHECKED BY: SOD RMF JOB NO.: 03250472.B0
PROJ. MGR.: DWZ CLIENT JOB #: H27-2821 50003714

PROJECT NAME :
CHILLER AND INFRASTRUCTURE REPLACEMENT - NORTH CH#2

PROJECT ADDRESS :
701 Park St, Columbia, SC 29208

DRAWING TITLE :
ELECTRICAL - DEMOLITION

DRAWING NUMBER :
ED-101



8

7

6

5

4

3

2

1

8 7 6 5 4 3 2 1

H

G

F

E

D

C


B

A

8 7 6 5 4 3 2 1



RMF ENGINEERING, INC.
194 SEVEN FARM DRIVE
SUITE G
CHARLESTON, SC 29492
P: 843-971-9639 F: 843-971-9641

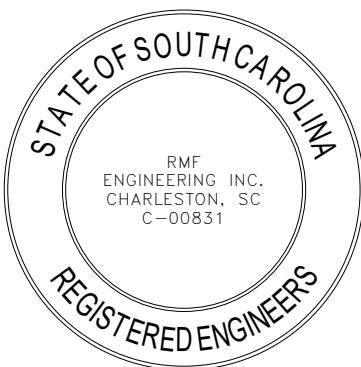

REV	DESCRIPTION	DATE

SUBMISSION TITLE :
Bid Documents

THIS DRAWING AND ALL COPIES THEREOF IS THE PROPERTY OF RMF ENGINEERING, INC. THIS DRAWING MAY NOT BE USED OR REPRODUCED WITHOUT ANY COMPUTER EQUIPMENT, OR BY ANY PHOTO MEANS, WITHOUT THE WRITTEN CONSENT OF RMF ENGINEERING, INC.

SEAL:

DRAWN BY: KJA DATE: 06/12/2026
DESIGNED BY: KJA SCALE: 1/8" = 1'-0"
CHECKED BY: SOD RMF JOB NO.: 03250472.B0
PROJ. MGR.: DWZ CLIENT JOB #: H27-2821 50003714

PROJECT NAME :
**CHILLER AND
INFRASTRUCTURE
REPLACEMENT - NORTH
CH#2**


PROJECT ADDRESS :
**701 Park St, Columbia, SC
29208**

DRAWING TITLE :
ELECTRICAL - NEW WORK


DRAWING NUMBER :

E-101

ELECTRICAL - NEW WORK
SCALE: 1/8" = 1'-0"

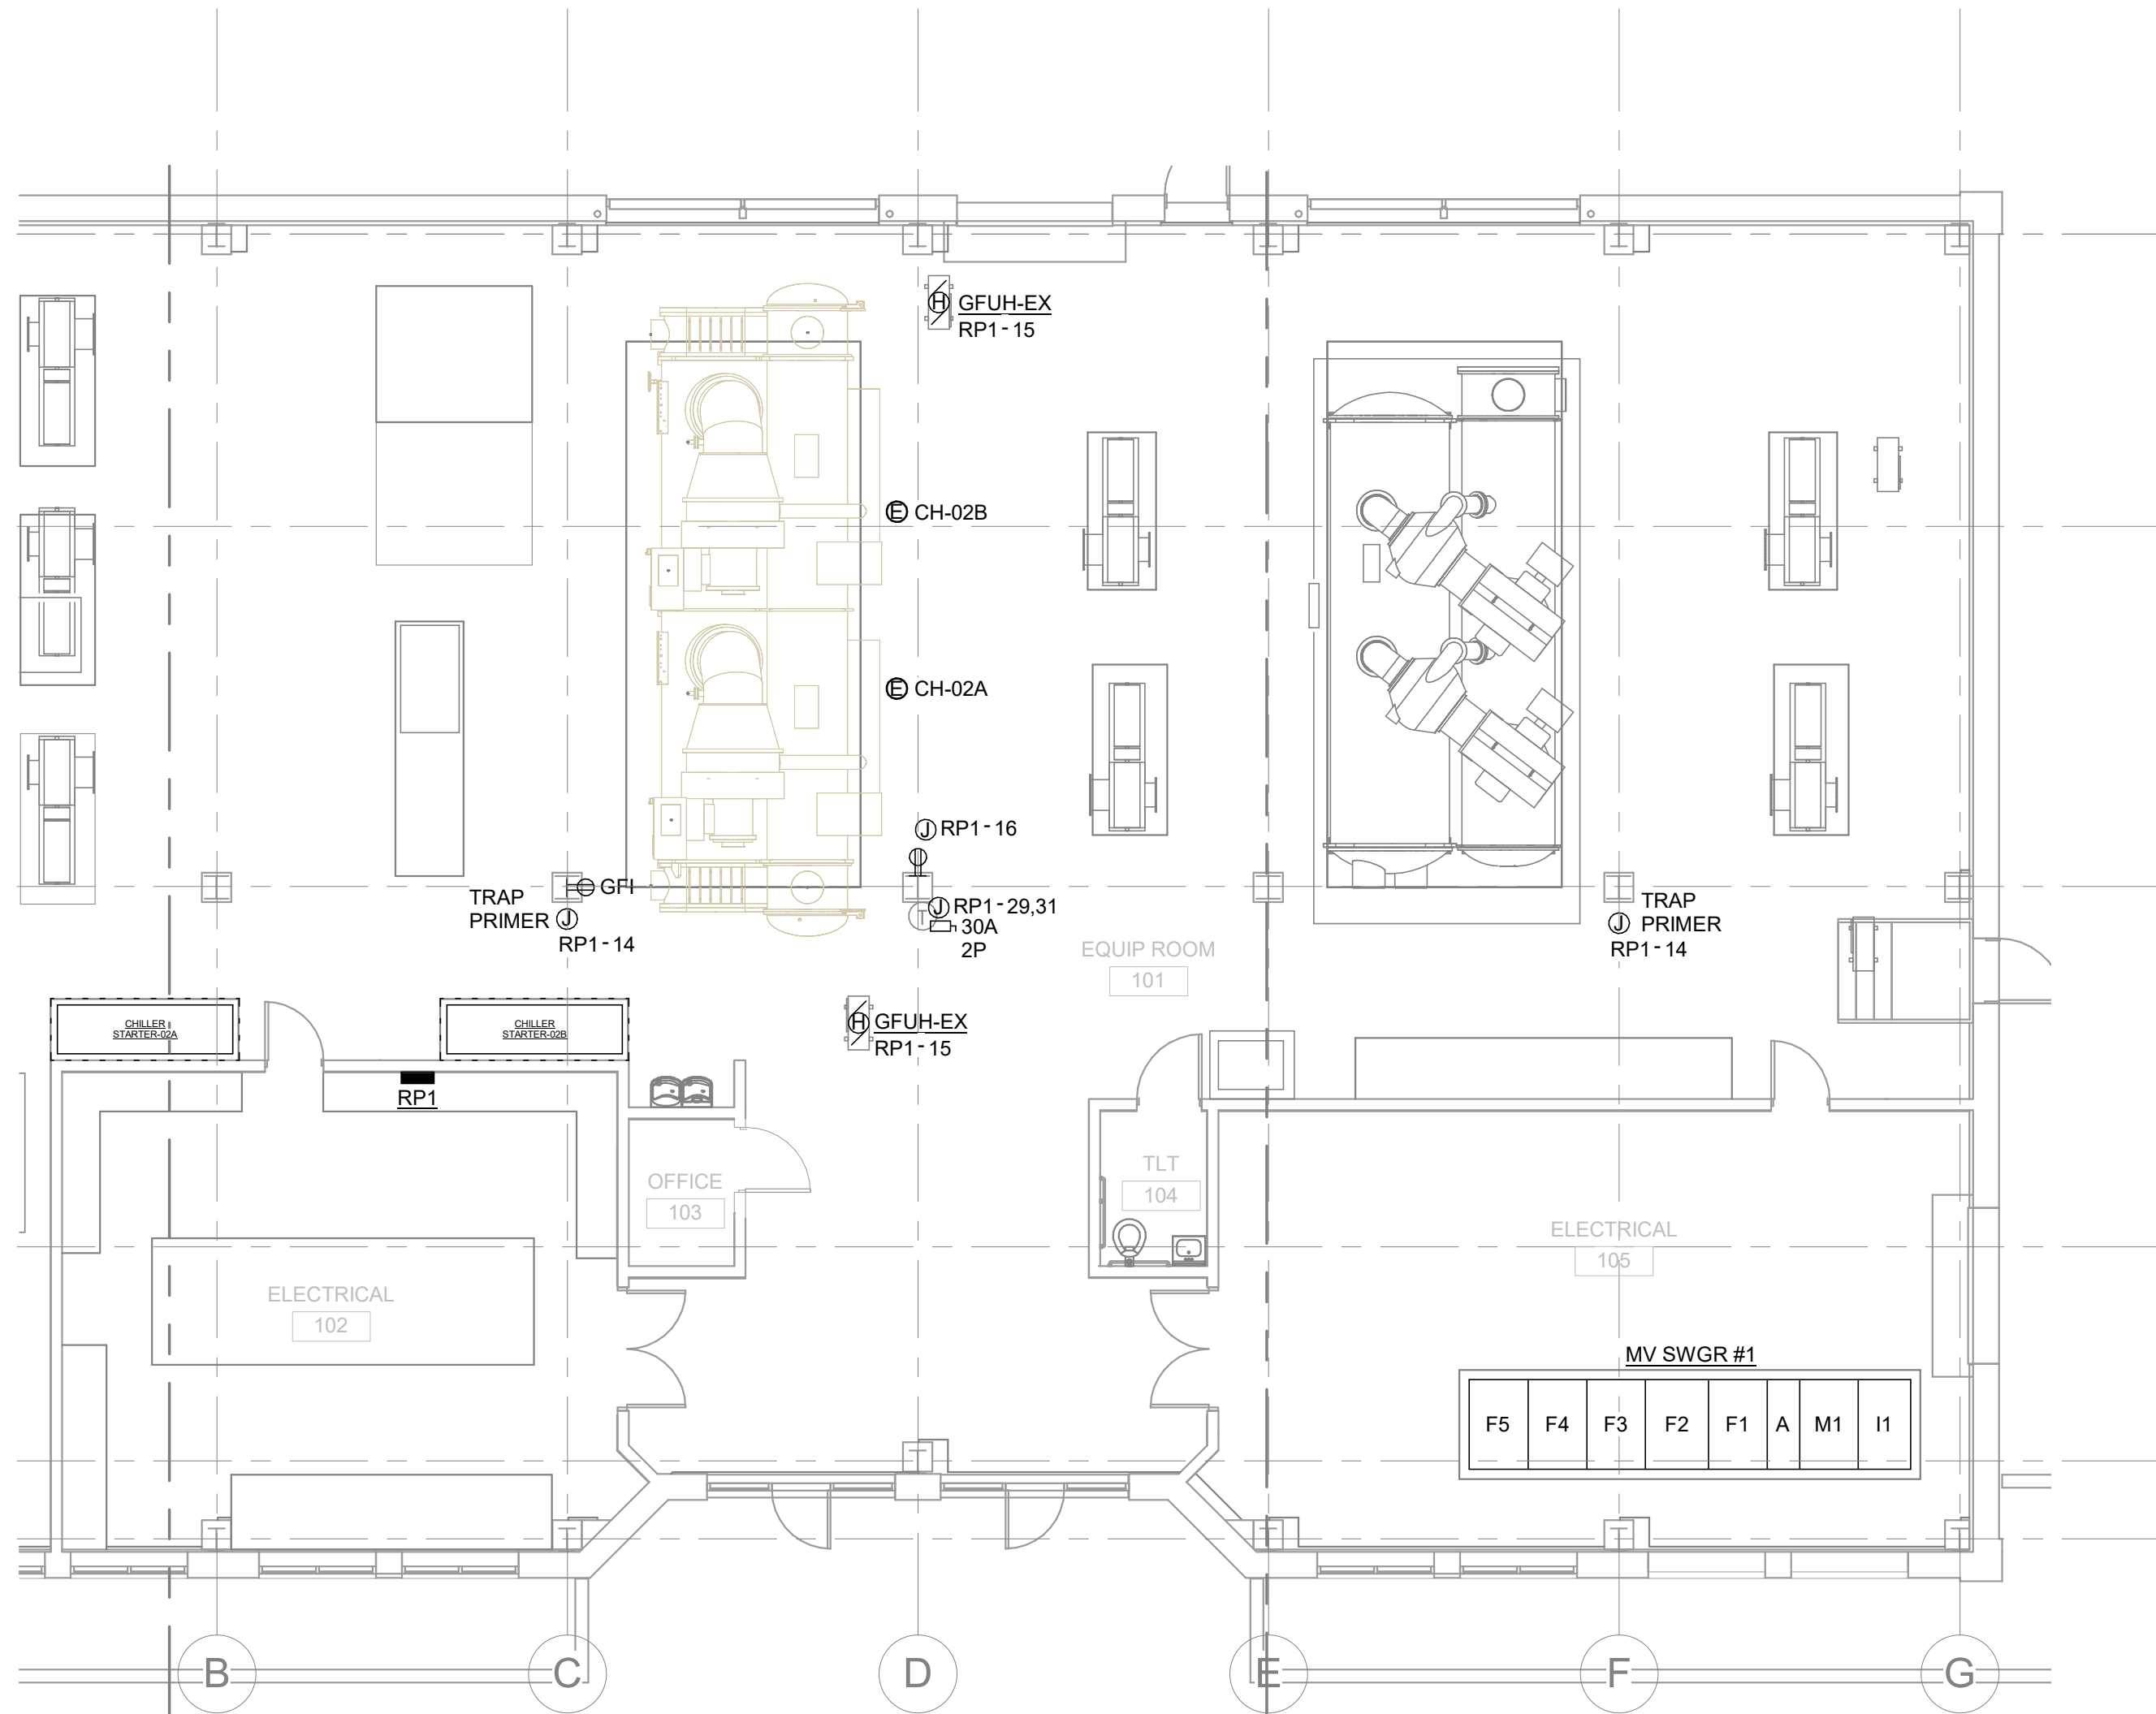

KEY PLAN

 

SCALE: 1/8" = 1'-0"

